

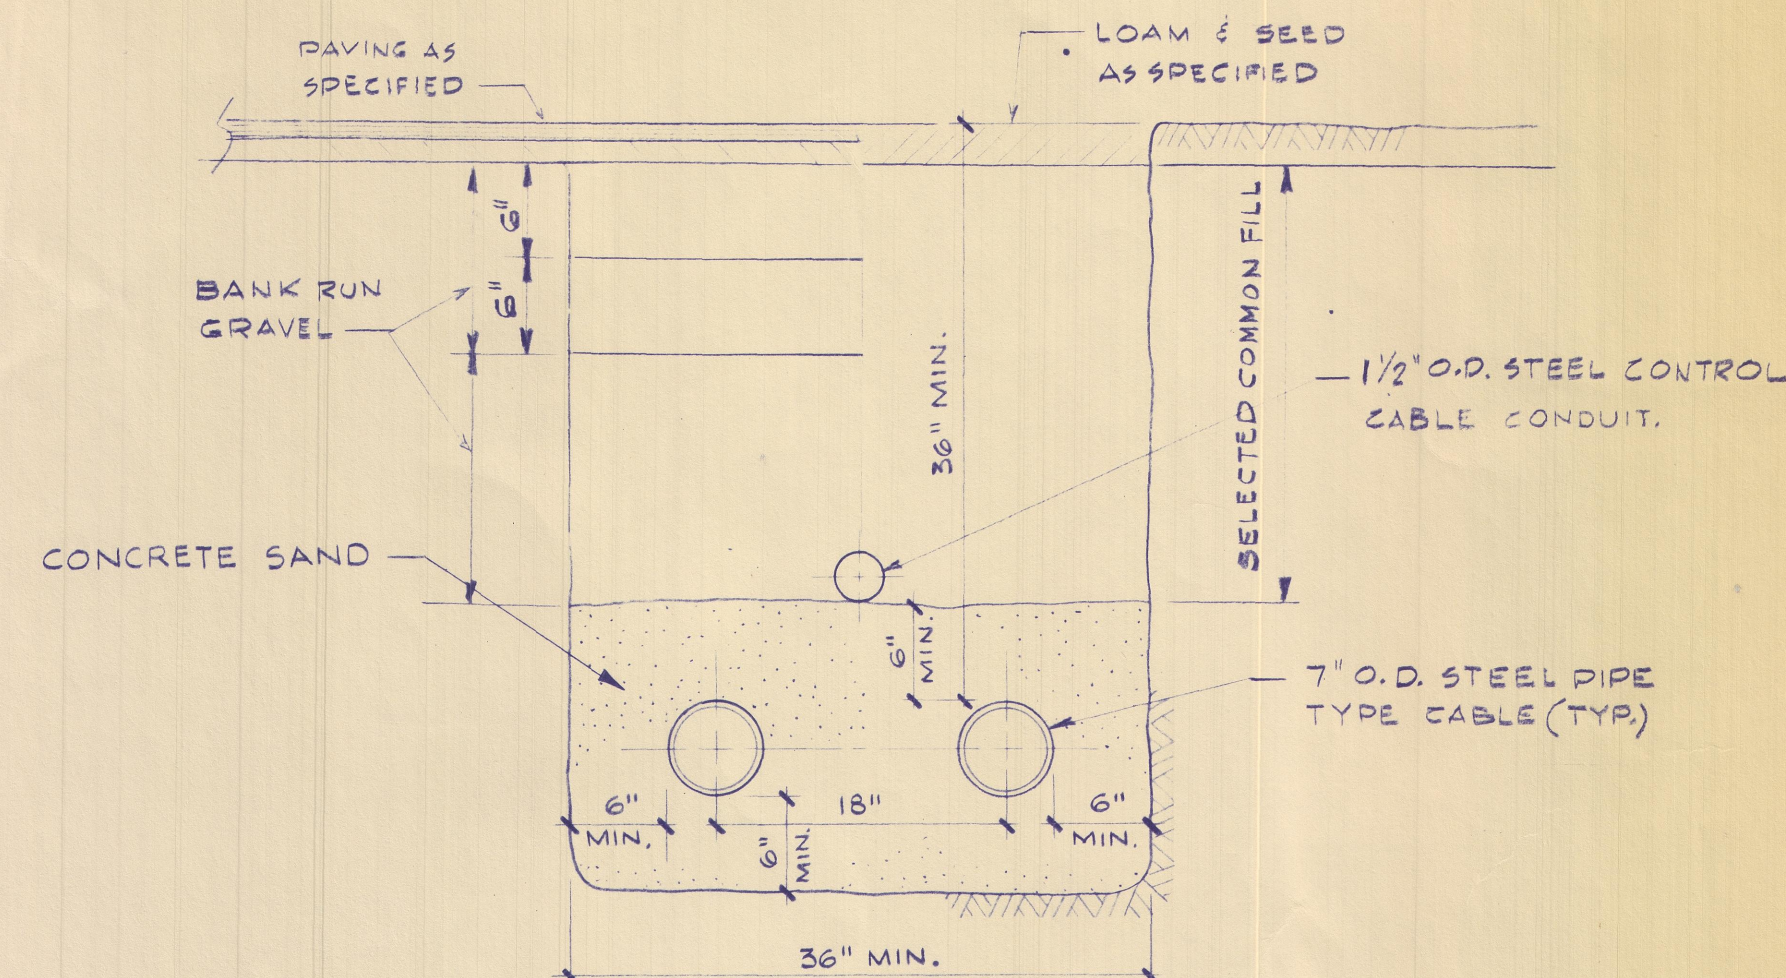
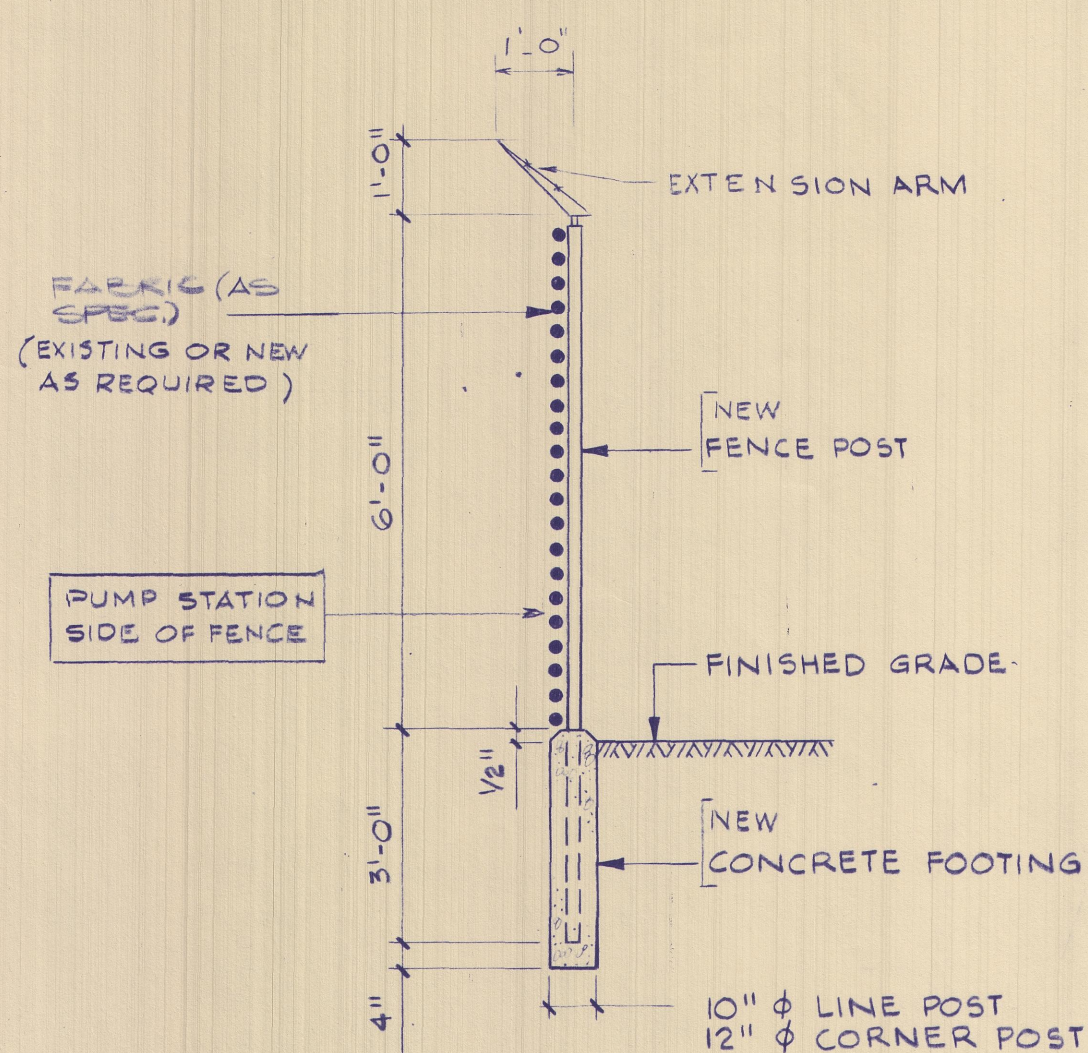
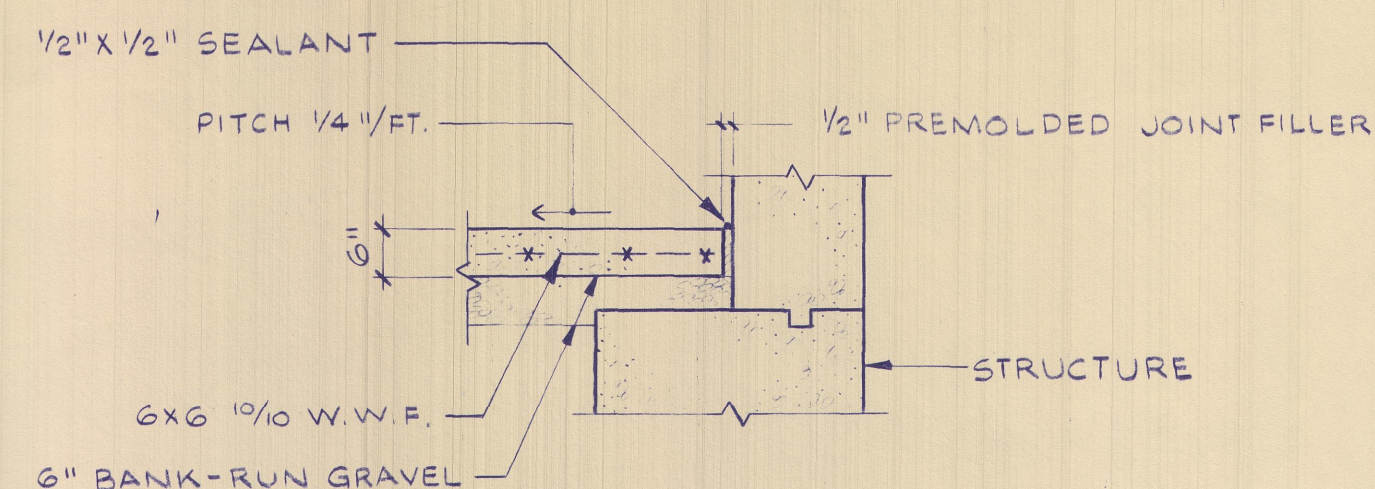
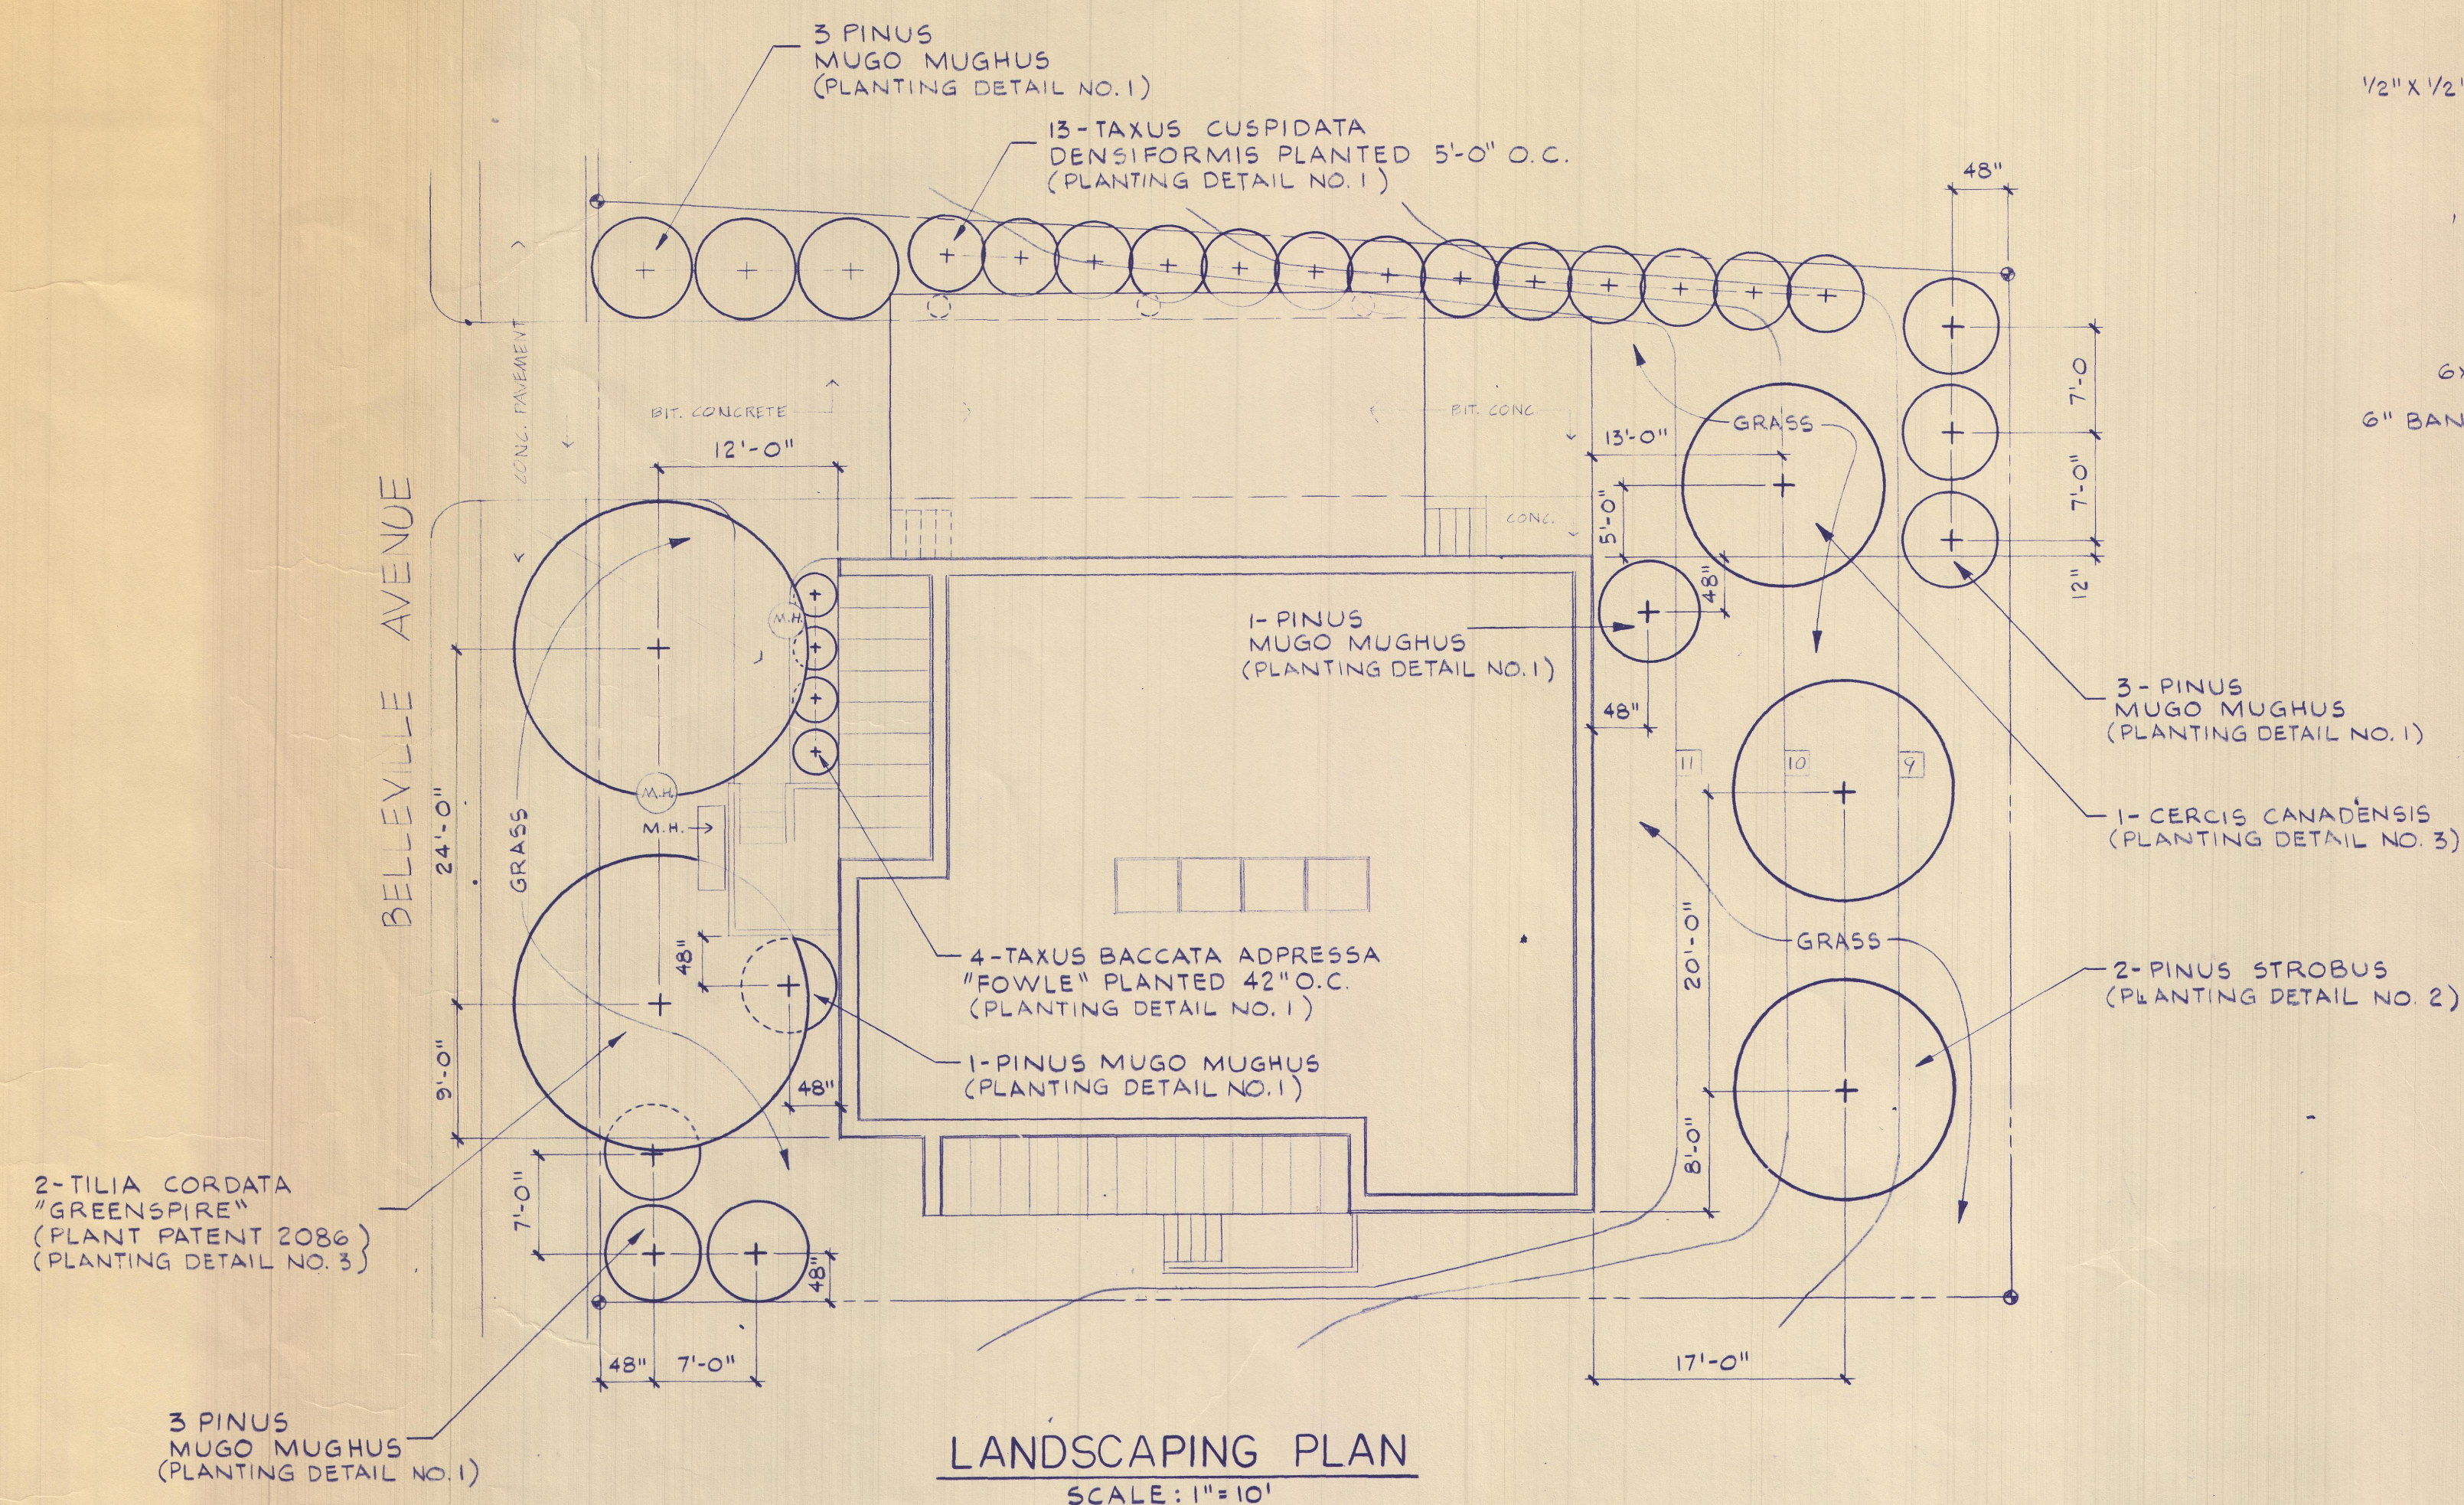
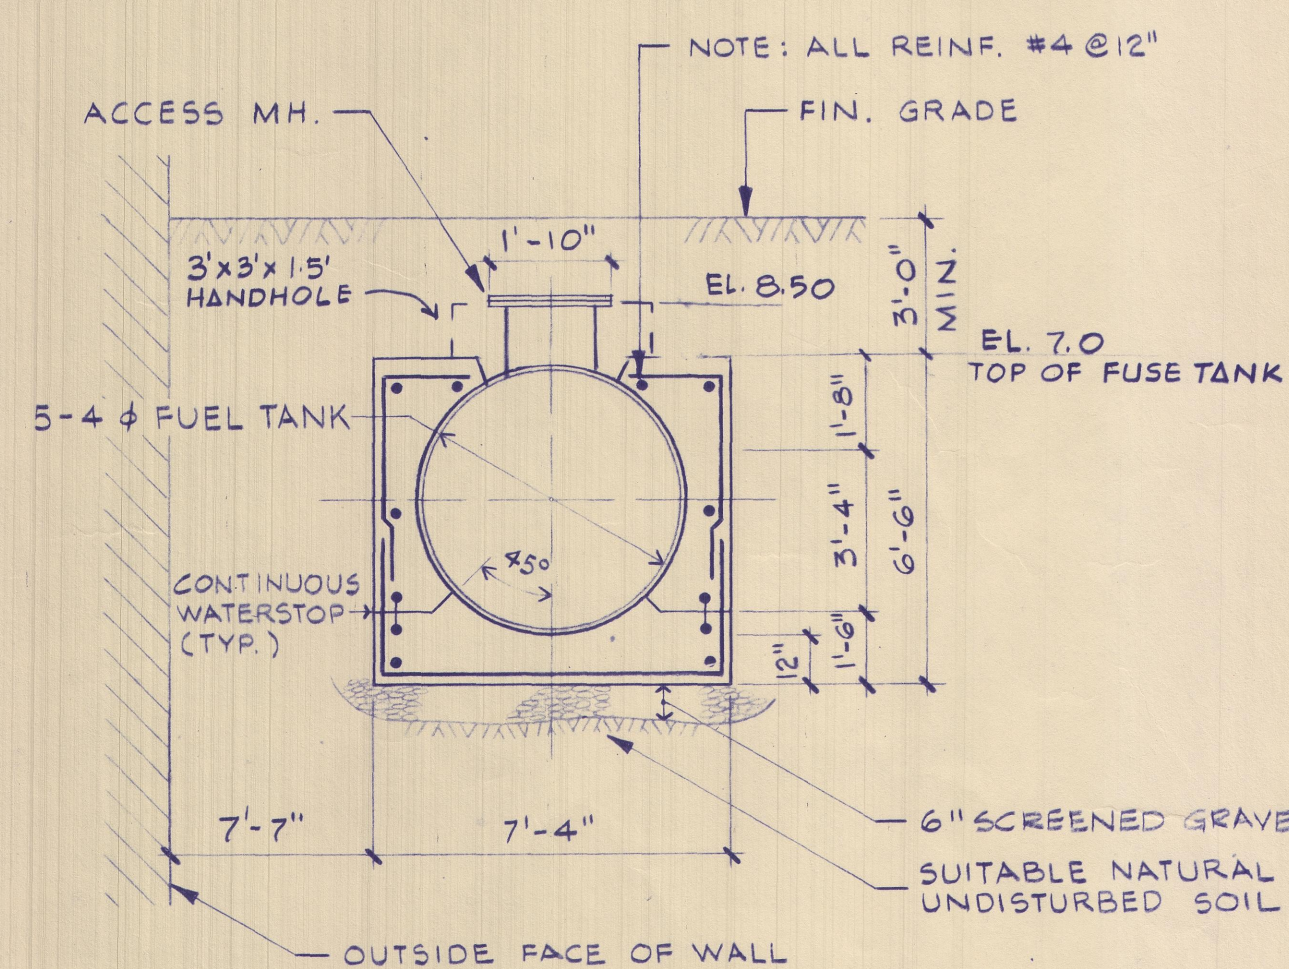
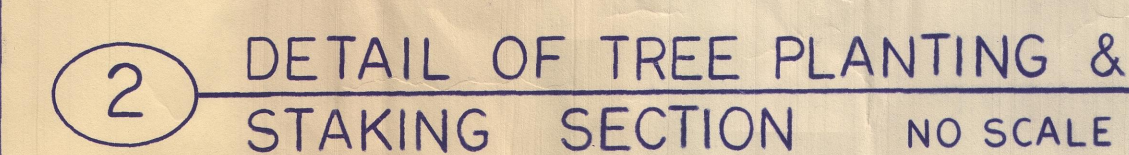


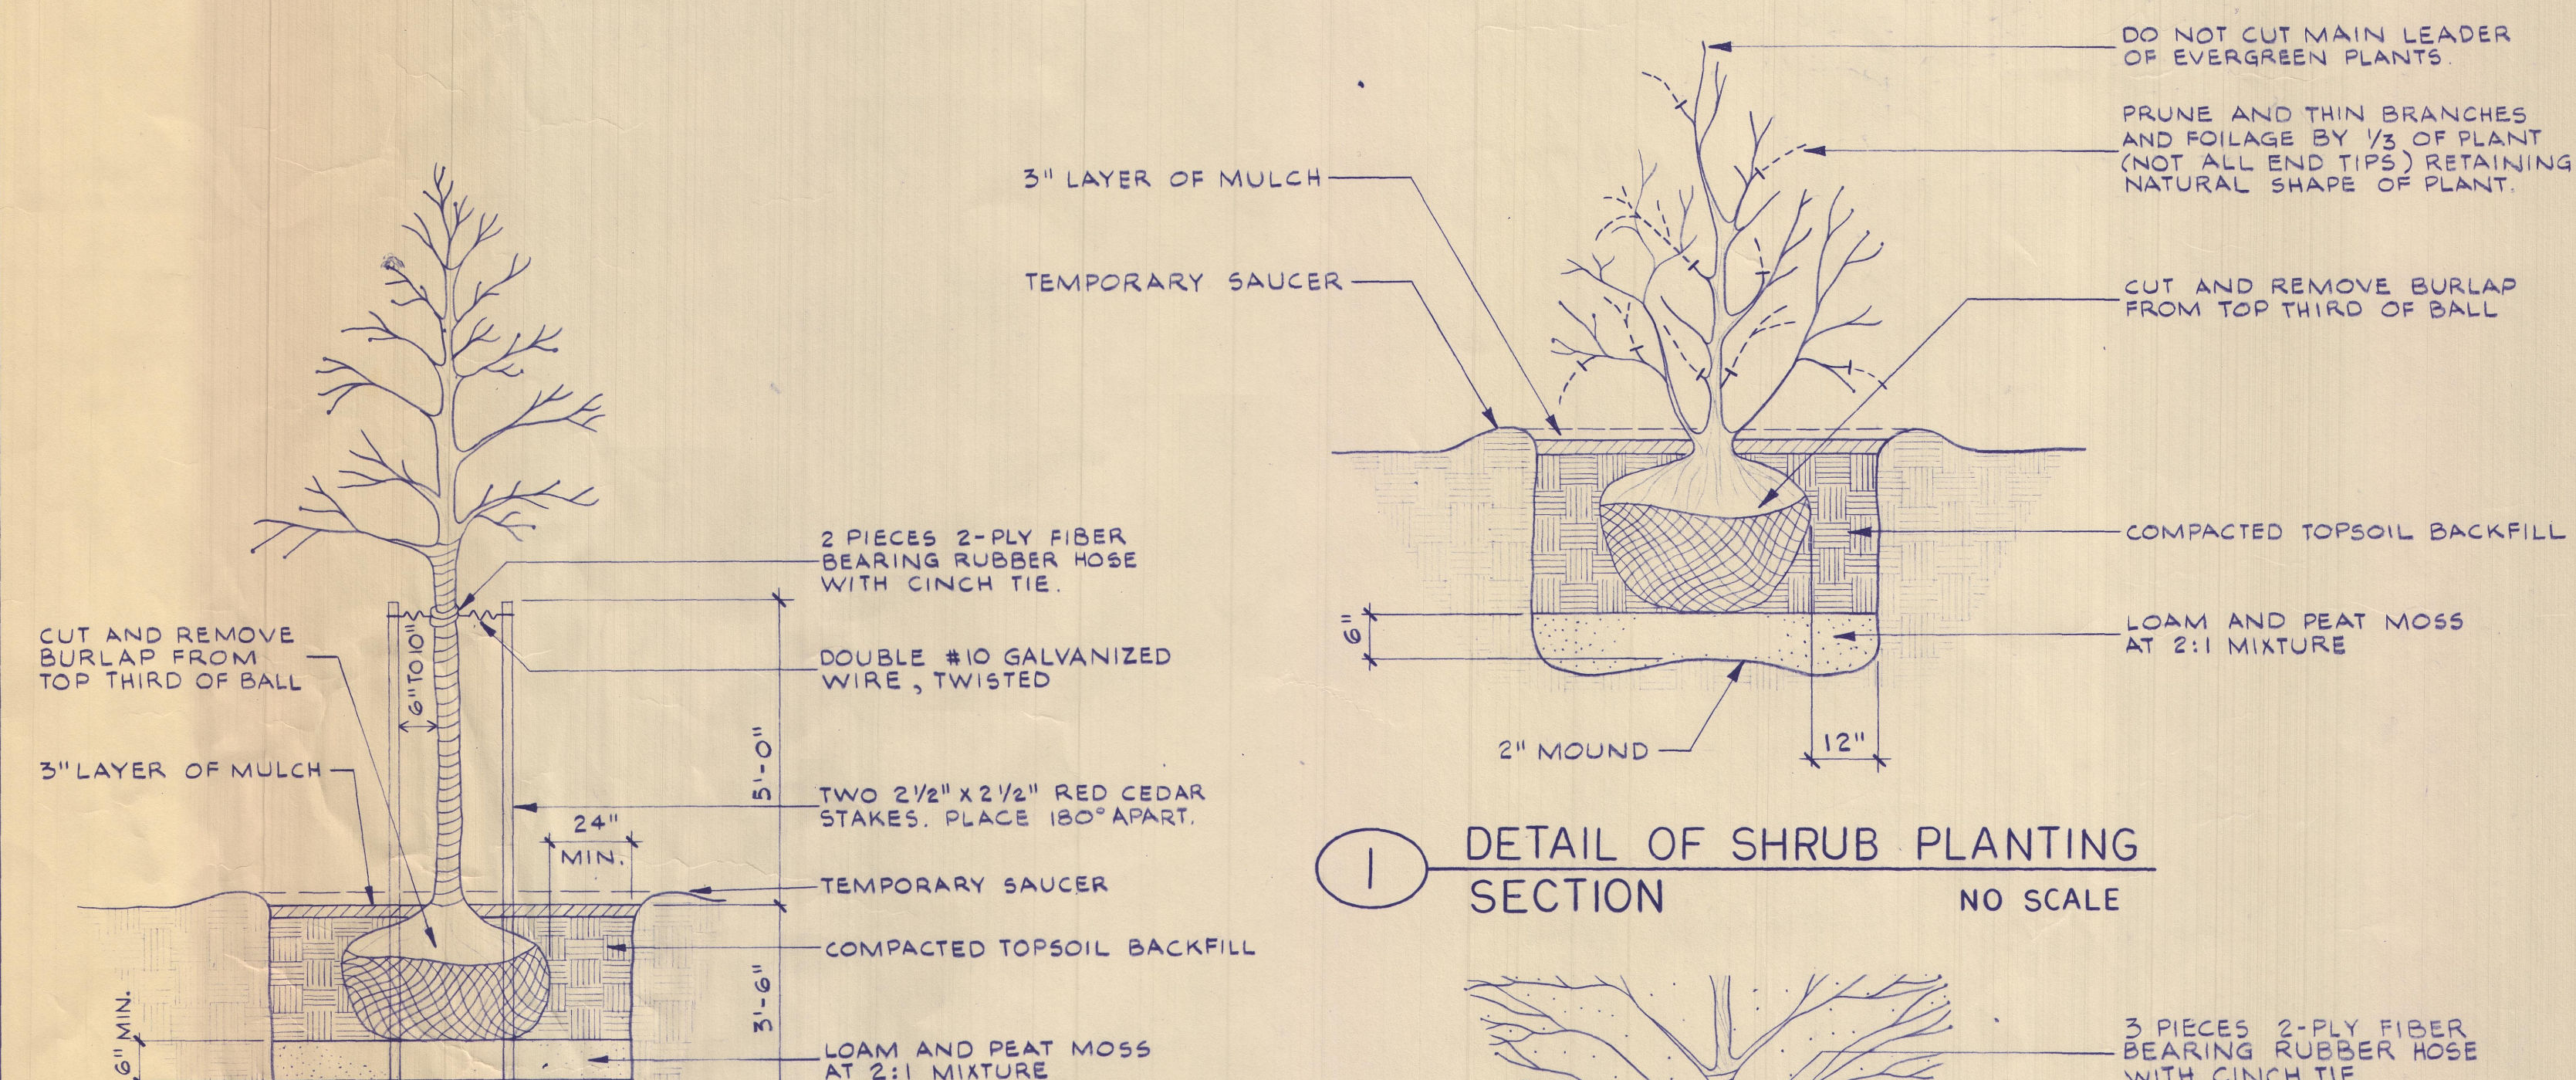

- NOTES:
1. CABLE TRENCH SECTION WAS PROVIDED BY THE NEW BEDFORD GAS & EDISON LIGHT CO, WITH BACKFILL & SURFACE RESTORATION BY CDM. BACKFILL MUST ALSO BE COORDINATED WITH UTILITY COMPANY.
  2. CABLE TRENCH SECTION PROVIDED FOR CONTRACTOR'S INFORMATION ONLY.
  3. EXCEPT FOR PAVING SUBBASE, PAVING, LOAM & SEED WORK AROUND CABLE OR CONDUIT WILL ONLY BE REQUIRED IF DISTURBED.

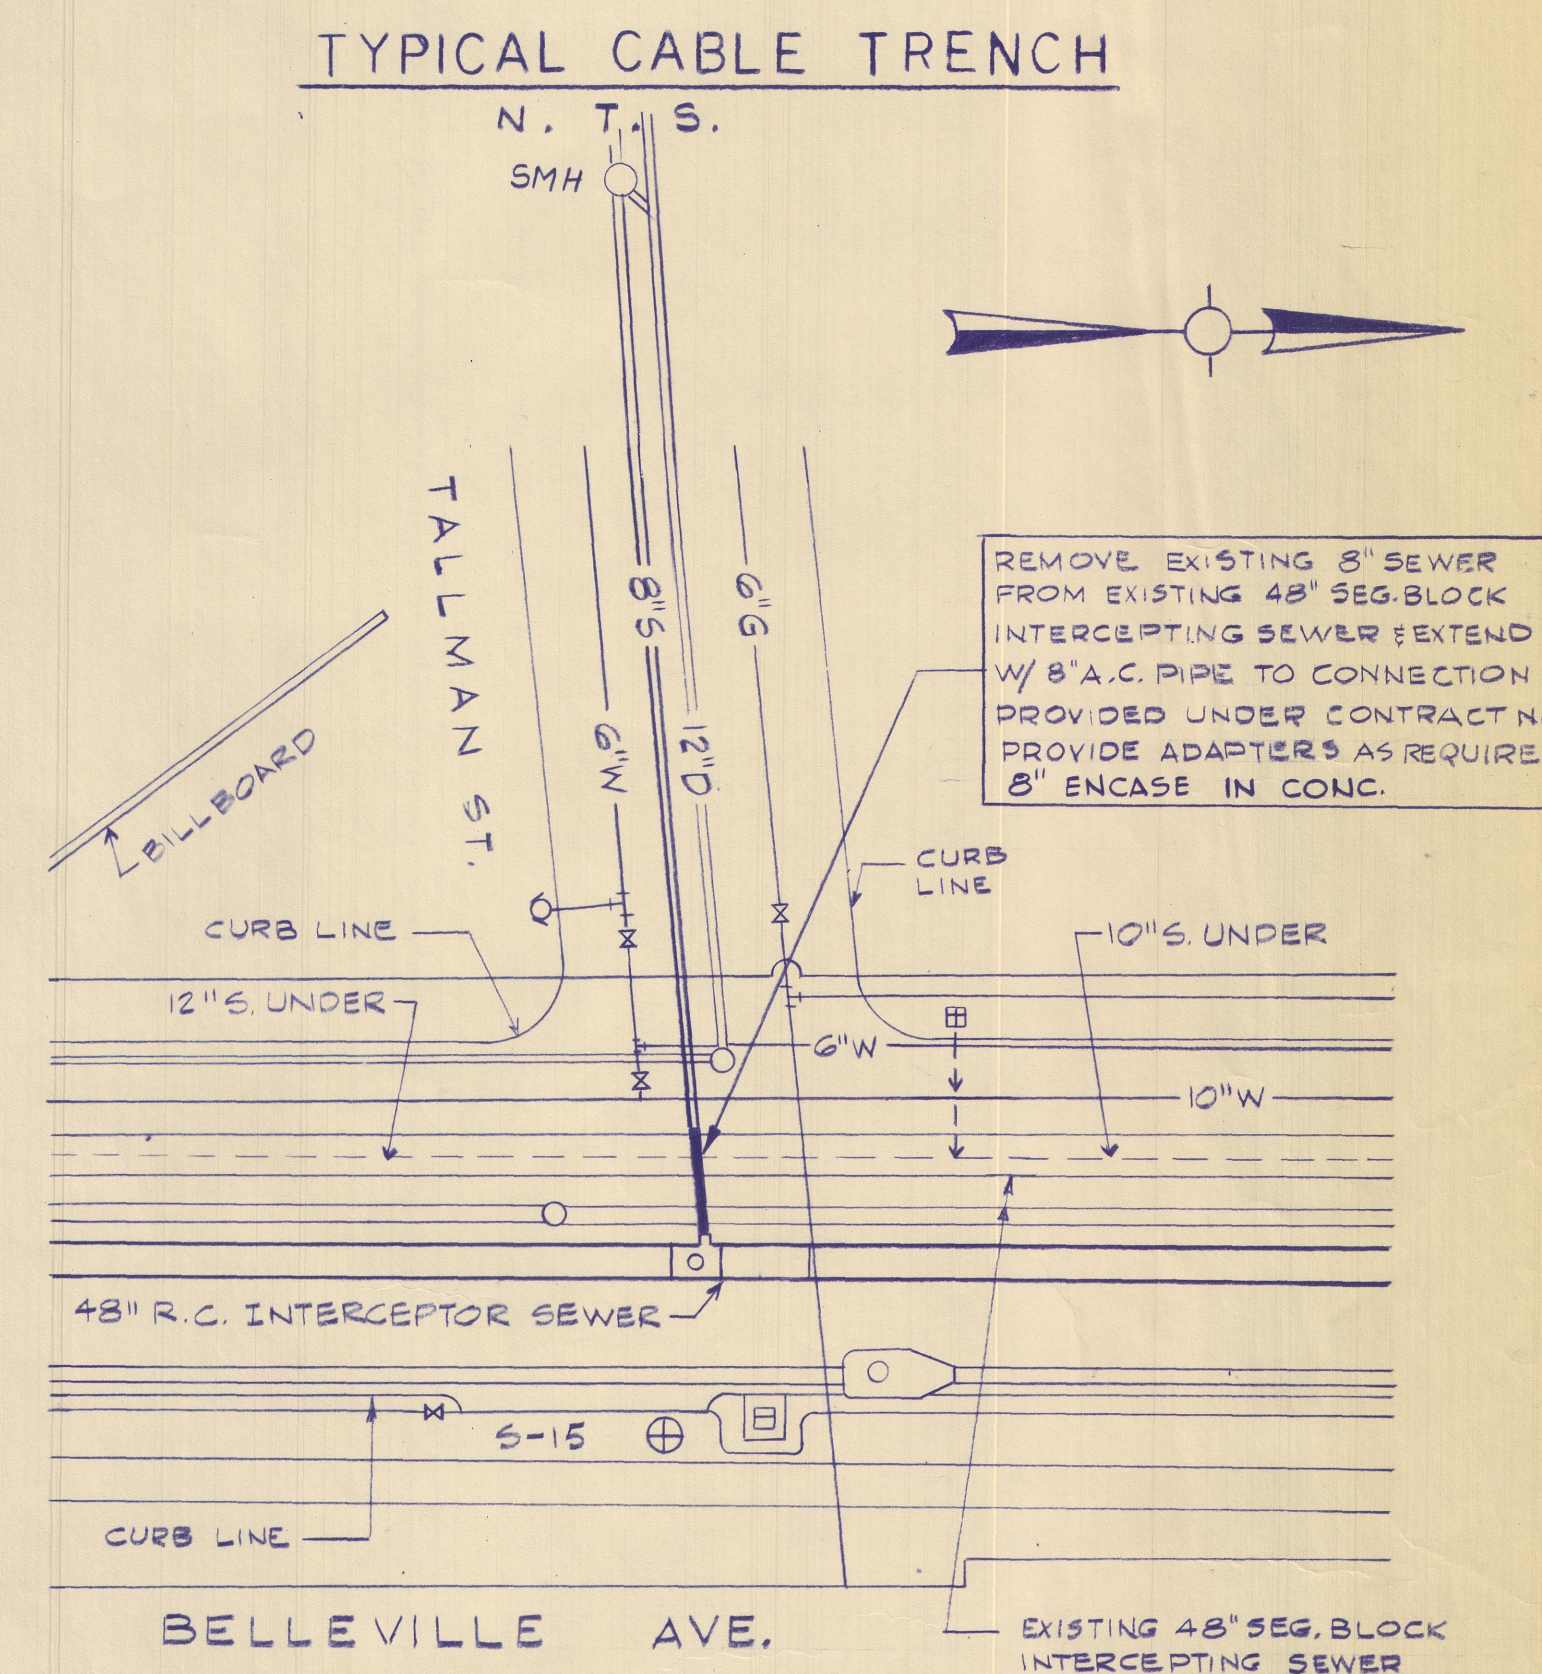


- NOTES:
1. CONTRACTOR SHALL FILL TANKS WITH WATER PRIOR TO PLACING ANY CONCRETE ABOVE MID-DIAMETER OF TANKS.
  2. FOR PIPE CONNECTIONS AND LOCATION OF FUEL STORAGE SEE SITE PLAN & SH. NO. HV-1
  3. CONCRETE ENCASEMENT SHALL BE 12 IN. (MIN.) ON ALL FOUR SIDES.

| Approved by:     | Date | Name         |
|------------------|------|--------------|
| Structural       |      |              |
| Electrical       |      |              |
| HVAC             |      |              |
| Project Engineer | 1/78 | B M Blodgett |
| Project Manager  | 1/78 | St. John     |

NOTE: PLACE GUYS 120° APART.  
WHEN TREE LOCATION IS SUCH  
THAT EQUAL GUY POSITIONING IS  
NOT WORKABLE SUCH AS NEAR  
PAVED AREAS AND ON SLOPES;  
GUY POSITION SHALL BE ADJUSTED  
TO MAXIMIZE STABILIZATION.

ANDREW T. JOHNSON CO., INC. 253

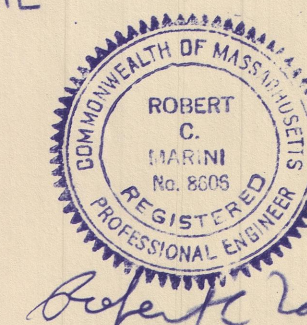

| Date         | Ch'k'd.       | Revision |                     |
|--------------|---------------|----------|---------------------|
| Designed by: | <u>EMR</u>    |          |                     |
| Drawn by:    | <u>J.H.M.</u> | Date:    | <u>OCTOBER 1977</u> |
| Checked by:  | <u>EMR</u>    |          |                     |
| Approved by: | <u>RCM</u>    | Scale:   | <u>AS NOTED</u>     |

|                                                                                                          |                                                                               |
|----------------------------------------------------------------------------------------------------------|-------------------------------------------------------------------------------|
| CITY OF NEW BEDFORD, MASSACHUSETTS<br>DEPARTMENT OF PUBLIC WORKS<br>WATER POLLUTION ABATEMENT FACILITIES |                                                                               |
| BELLEVILLE AVENUE WASTEWATER PUMPING STATION<br>PROJECT NO. B-53, CONTRACT NO. I                         |                                                                               |
| MISCELLANEOUS DETAILS I                                                                                  |                                                                               |
|                     | <b>CAMP DRESSER &amp; McKEE Inc.</b><br>Consulting Engineers<br>Boston, Mass. |
|                                                                                                          | SHEET NO.<br>G-2<br>309-28507                                                 |