

(new) SEWER 20053

SERVICE 34169

Domestic

W-22-13

NEW BEDFORD WATER WORKS

APPLICATION FOR SERVICE AND METER

NEW BEDFORD

6.3.2022

expires: 6.3.2023

I HEREBY ACKNOWLEDGE the receipt of a copy of the Regulations prescribed in the Ordinance of the City, for the use of Water, and I request that the water may be furnished through a

4"

inch

CLIP

meter at 198 Herrens Melville Blvd

Proposed alterations to Existing Bldg for Packaging Products Corp

at such rates as may from time to time be established by the City.

I hereby agree to pay promptly the bill for the Service pipe laid down for my premises, and to pay all dues for water, and I agree to conform to the said Regulations and to all provisions of the Water Ordinances, until written notice is given by me or my agent to cut off the supply.

P. 64

L. 153/153A

TB-22-631

Patridge:

774-991-5211

Bristol Community College

TELEPHONE 774-357-2189

777 Elm St Fall River MA

02720

Service laid 4" tap into 12" water main on Herrens Melville Ave

Size and kind of pipe

From contractor: B&B excavation

St.

Turned on Meter Set

Reading Location

Building rates Paid

Cost of Service

\$725

chk#

1085

returned 1085 wrong dollar amount

received check 1087

see attached

31-727

4" – Ductile – Fire Supply 06/27/2022

Contractor DF Pray, Inspector Percy Reynolds

E X E Herman Melville Blvd	273'
N X S Harvey Tichon	15'
E X W Build	93.8'
W X E Build	16'
N X N Build	23.8
Main to property line	16'
Pipe inside property	11'

DF Pray Inc
Registration and Permit Fee Account
25 Anthony Street
Seekonk, MA 02771

53-447/113

1087

DATE 6/21/22

PAY TO
THE ORDER OF

City of New Bedford

\$ 725.00

Seven Hundred and Twenty-Five ⁰⁰/₁₀₀

DOLLARS

Rockland Trust

CHECKS NOT TO EXCEED \$2500.00

MEMO OF-02448 18+Union



Nancy Ann Dye
AUTHORIZED SIGNATURE

MP

⑈001087⑈ ⑆011304478⑆ 7457004021⑈

(new) SEWER 95053
SERVICE 34169
DOMESTIC

expires: 6.3.2023
NEW BEDFORD WATER WORKS
APPLICATION FOR SERVICE AND METER
NEW BEDFORD 6.3.2022

I HEREBY ACKNOWLEDGE the receipt of a copy of the Regulations prescribed in the Ordinance of the City, for the use of Water, and I request that the water may be furnished through a

4" inch CLIP meter at 198 Herman Melville Blvd

Proposed alterations to Existing Bldg fka Packaging
at such rates as may from time to time be established by the City. Producers Corp

I hereby agree to pay promptly the bill for the Service pipe laid down for my premises, and to pay all dues for water, and I agree to conform to the said Regulations and to all provisions of the Water Ordinances, until written notice is given by me or my agent to cut off the supply.

P. 64
L. 153/153A

TB-22-631

TELEPHONE 774-357-2189 774 215Braz & Fall River Rd
Belvid Community College

Service laid 4" tap into 12" watermain on Hervey Tichon Ave
Size and kind of pipe

From contractor: BAB excavation

St.

Turned on Meter Set

Reading Location

Building rates Paid

Cost of Service

31-727

\$725

chkd

1085

released 6-22-2022 incorrect amount

1087 taken 6-22-2022

DISPLAY PERMIT IN A CONSPICUOUS PLACE ON THE PREMISES



Commonwealth of Massachusetts

City of New Bedford

133 William Street New Bedford, MA 02740

WATER SERVICE PERMIT



Date: 7/11/2022

No. **W-22-13**

Permit Fee: \$725.00

Service Location: 198 HERMAN MELVILLE BLVD

Owner Name: SEAWARD RESOURCES INC

Owner Phone #: (774) 357-2189

Type of Occupancy: Industrial

Type of Work: Water - Domestic New 4"

Work Description: 34169-Domestic;
p.66-l.153/153a

service laid 4" tap into 12" water main on Hervey tichon ave-
proposed alteraions to existing bldg fka packaging products corp.

Contractor

Name: _____ Certificate #: _____ Type of Business : _____

Address: _____ City/Town/State: _____ Phone #: _____

Type of Service _____ Pipe Size _____ Trench Length: **0.00**

Fire Service _____

Domestic Service _____

Estimated consumption of water

Estimated average daily consumption 0.00 gallons

Cross Connection? **No**

Estimated maximum day consumption 0.00 gallons

Right of Way? **No**

Are lawn sprinklers and/or lawn irrigation proposed on site? **No**

Meter Impact? **No**

Estimated fire flows required for the project site: 0.00

Street Opening Permit Required? **No**

Does the project require a fire supression system? **No**

Required minimum static pressure for the proposed project site 0.00

Call Phone: (781) 942-9077 For Inspection

DISPLAY PERMIT IN A CONSPICUOUS PLACE ON THE PREMISES



Commonwealth of Massachusetts

City of New Bedford

133 William Street New Bedford, MA 02740




WATER SERVICE PERMIT GRANTED WITH THE USUAL CONDITIONS








Water

COMMISSIONER

Call Phone: (781) 942-9077 For Inspection

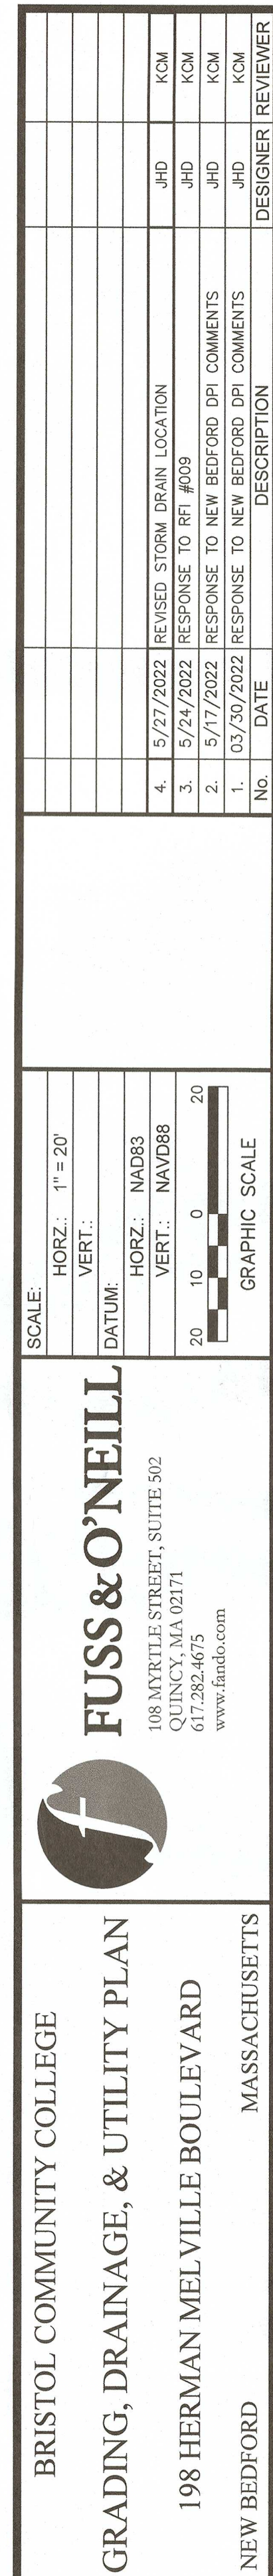

CG-101

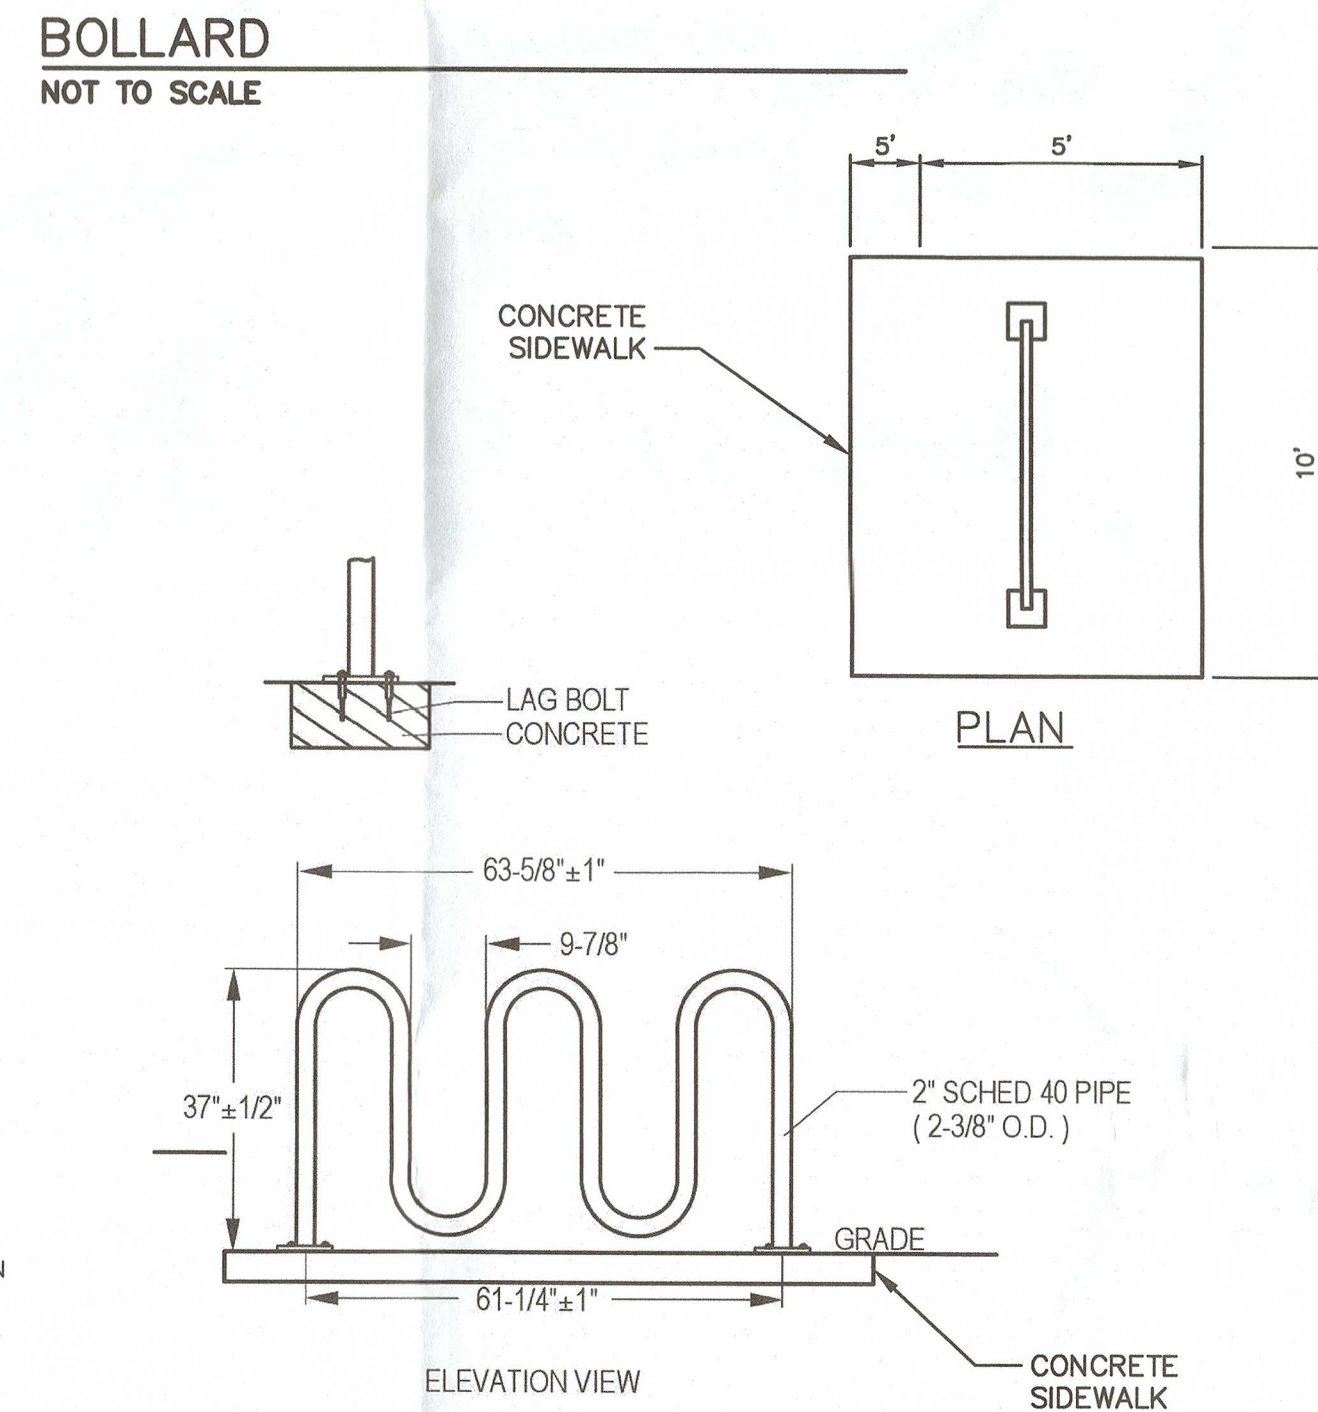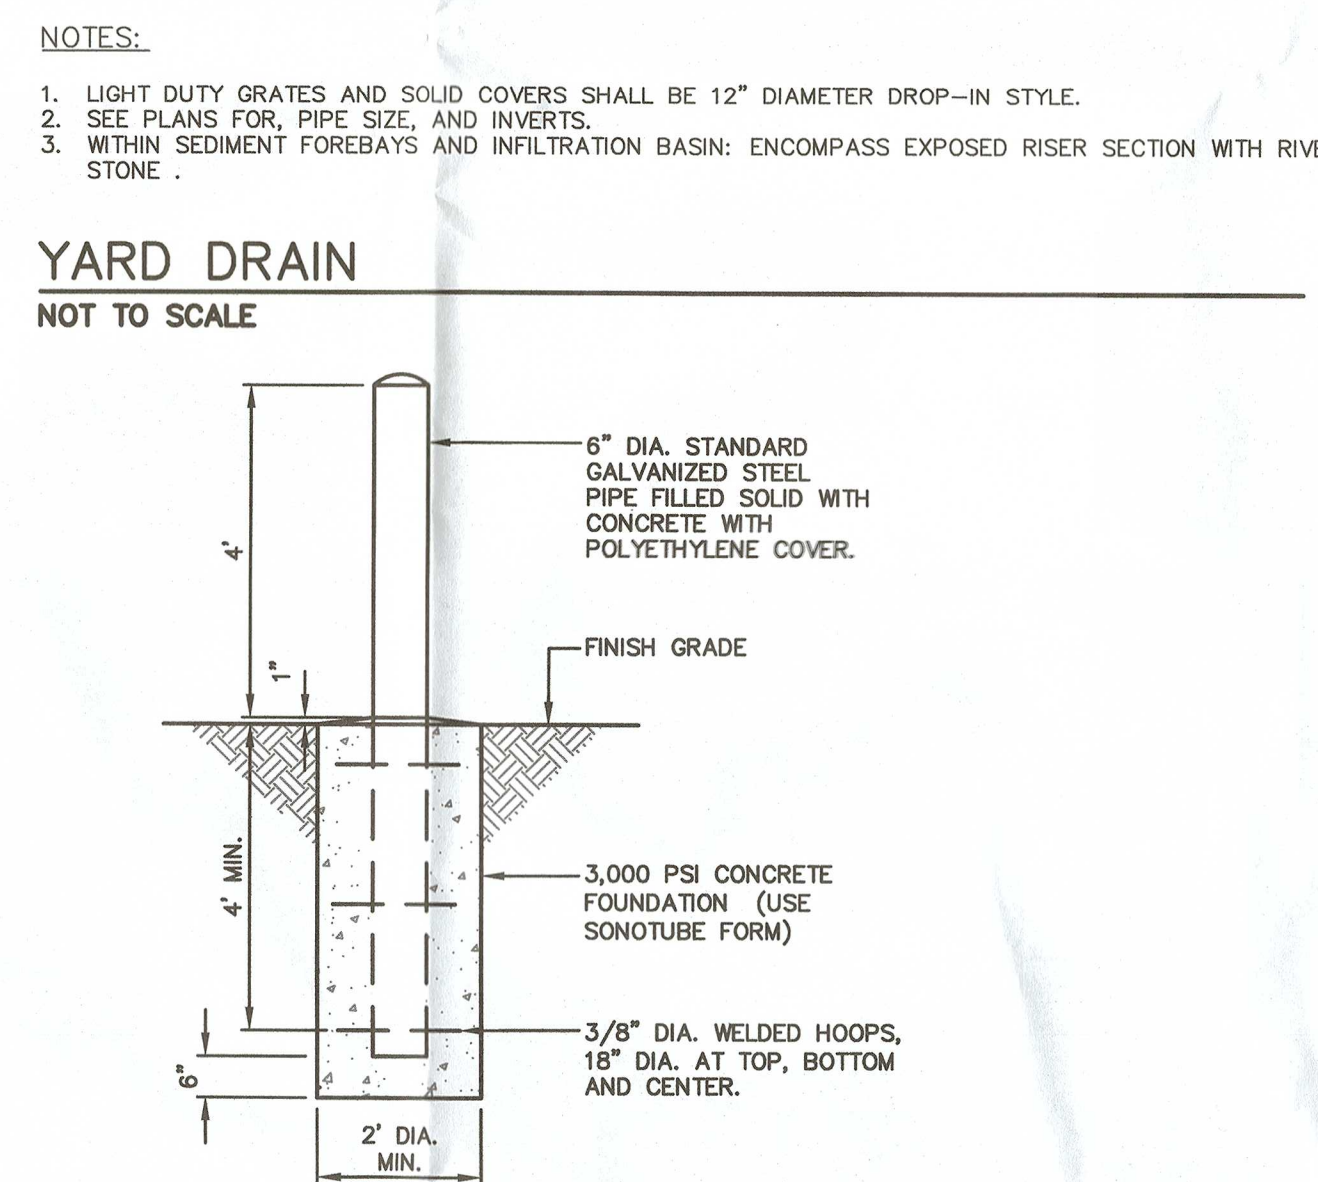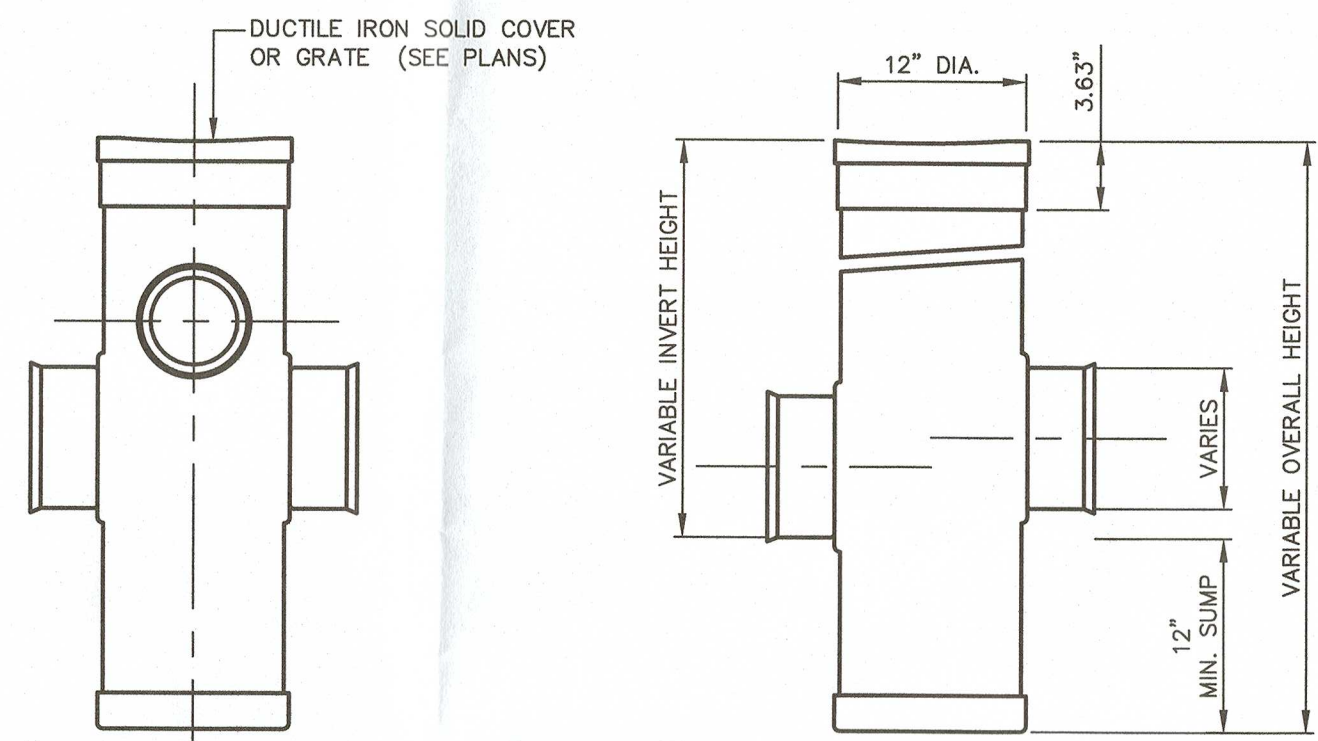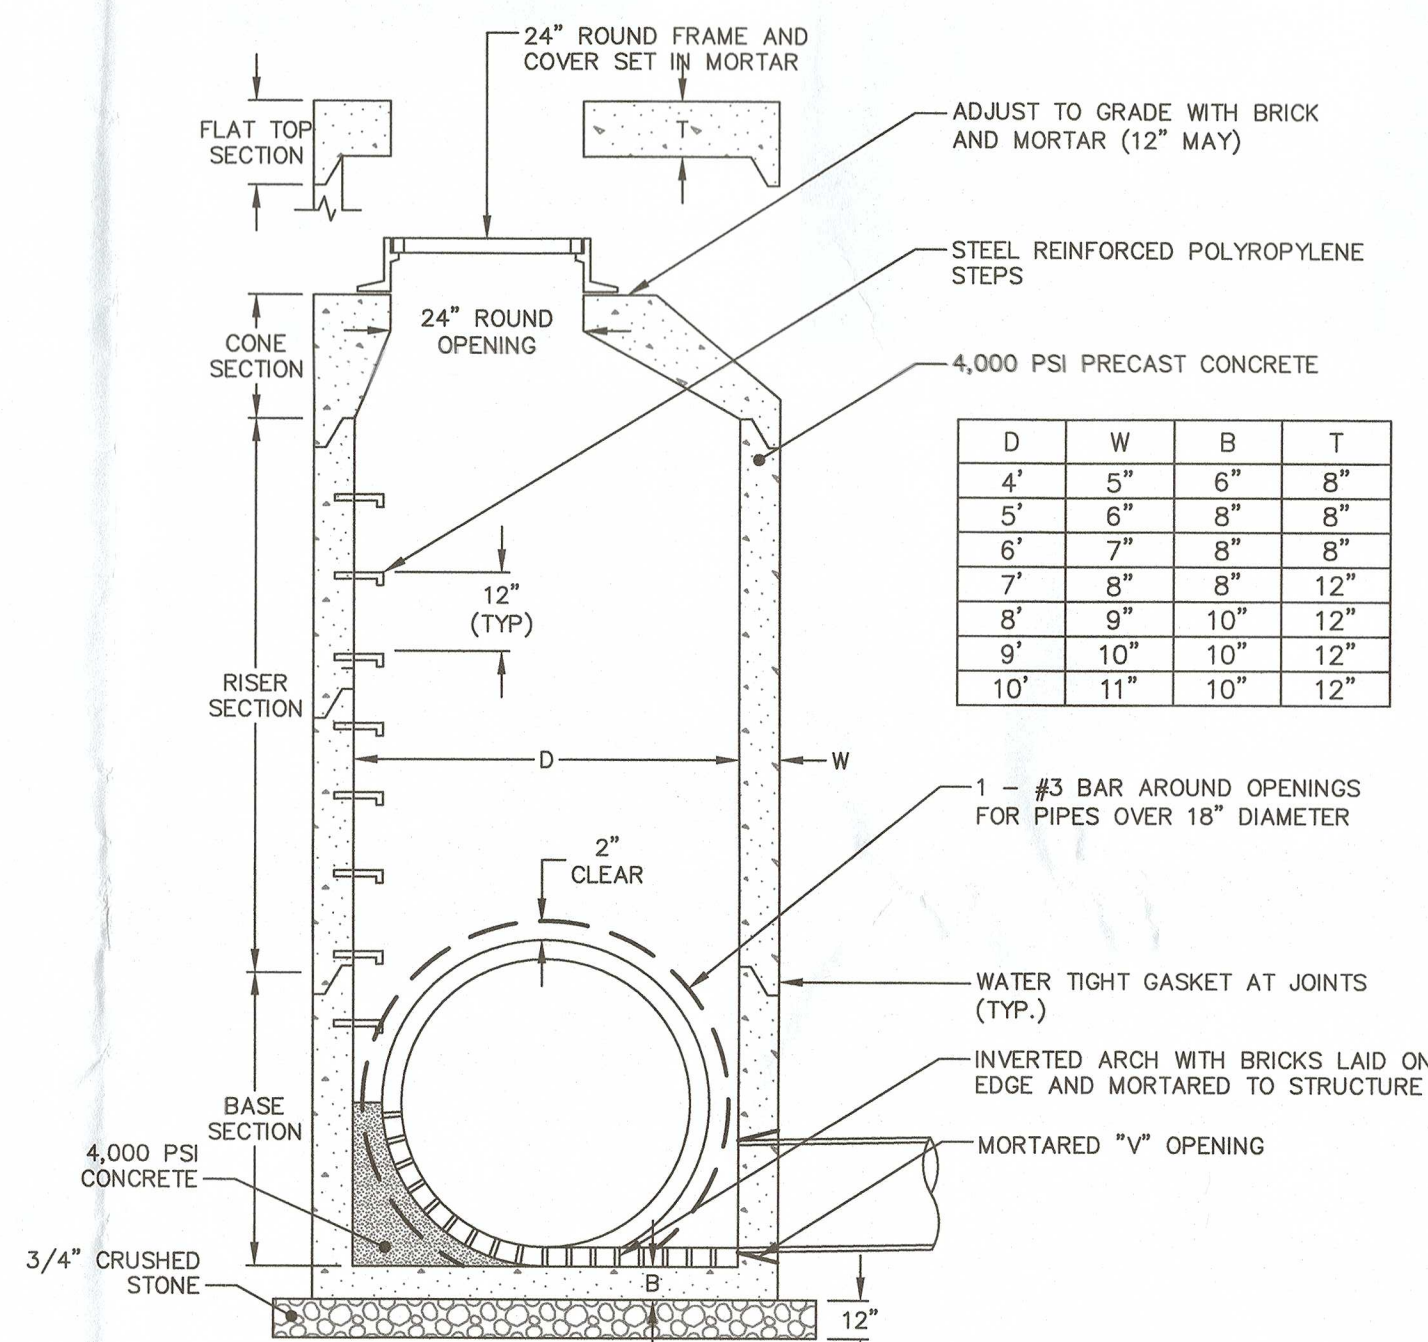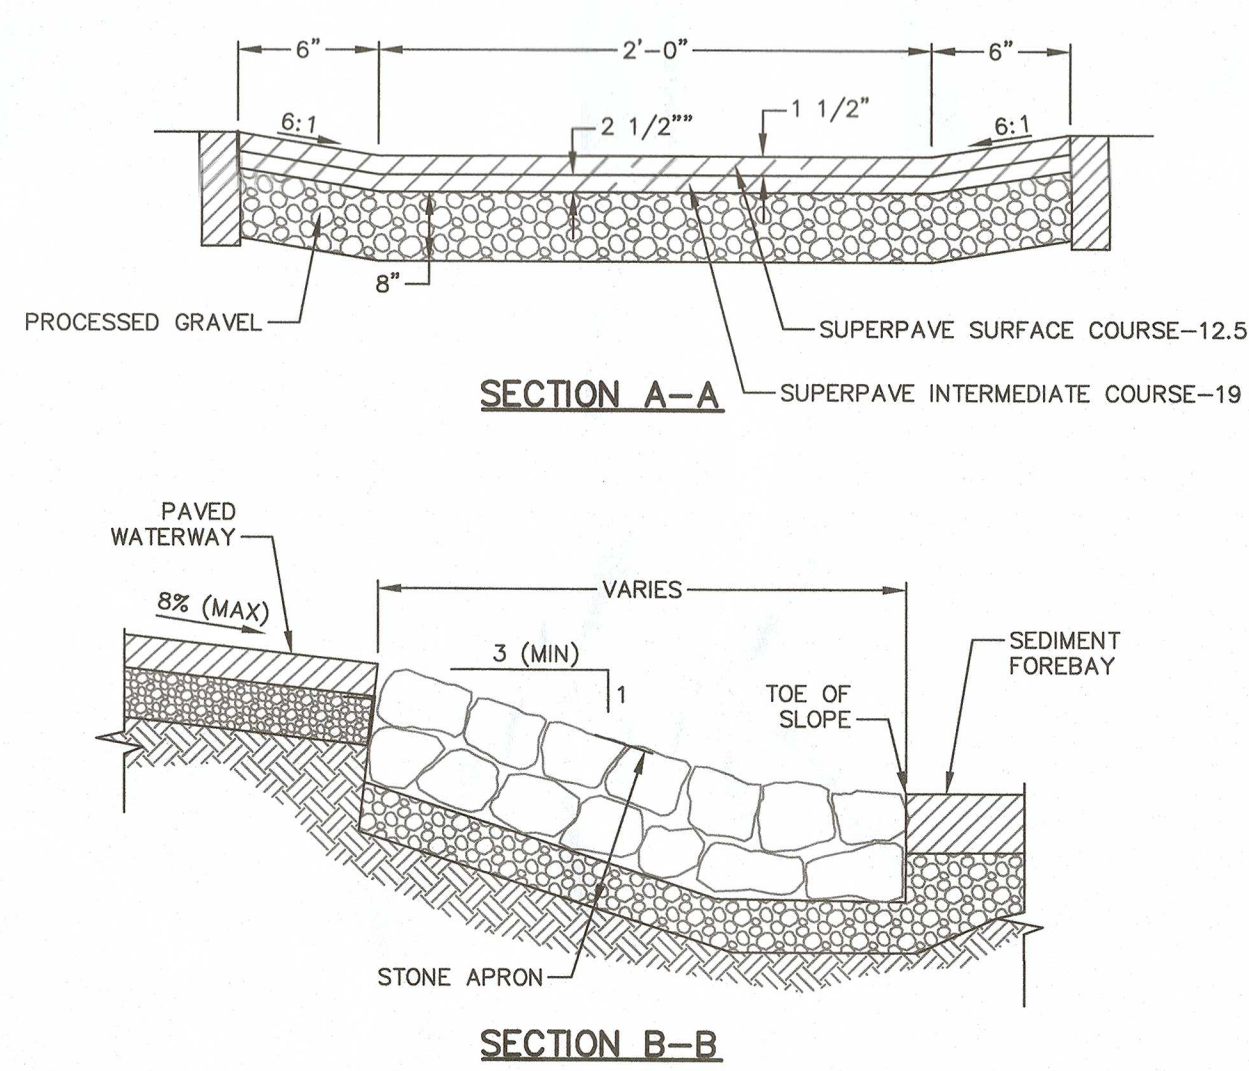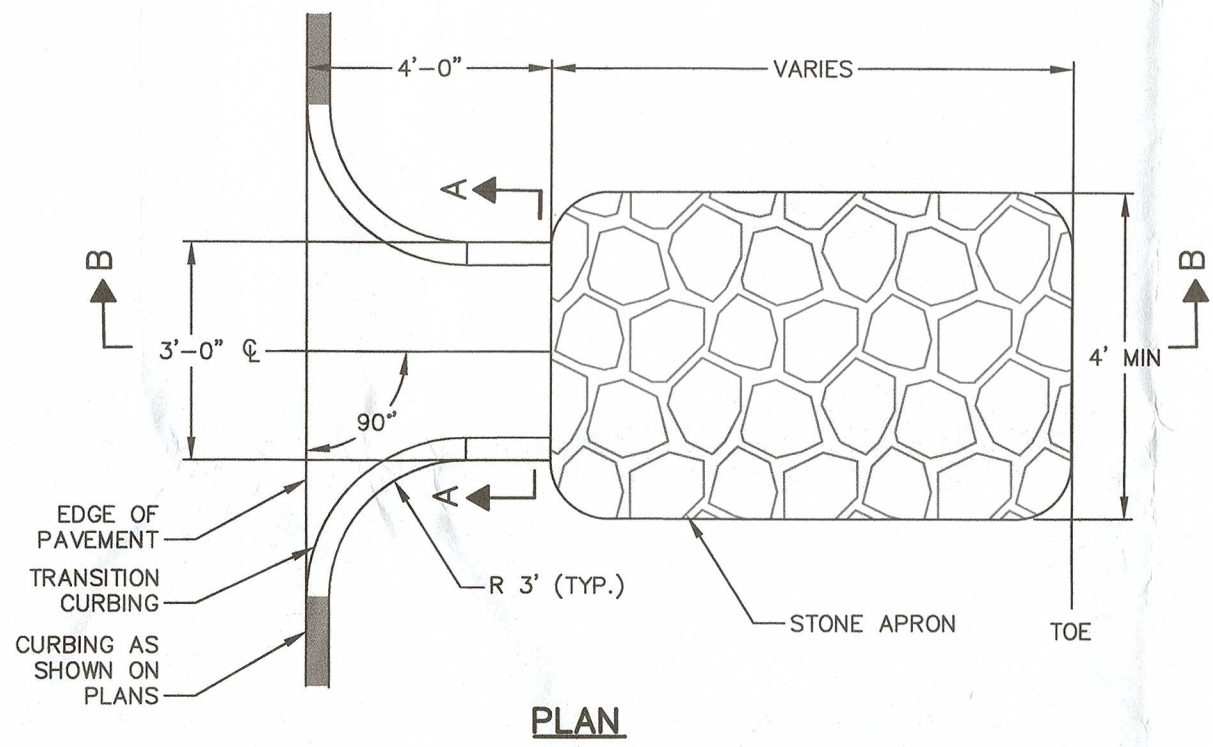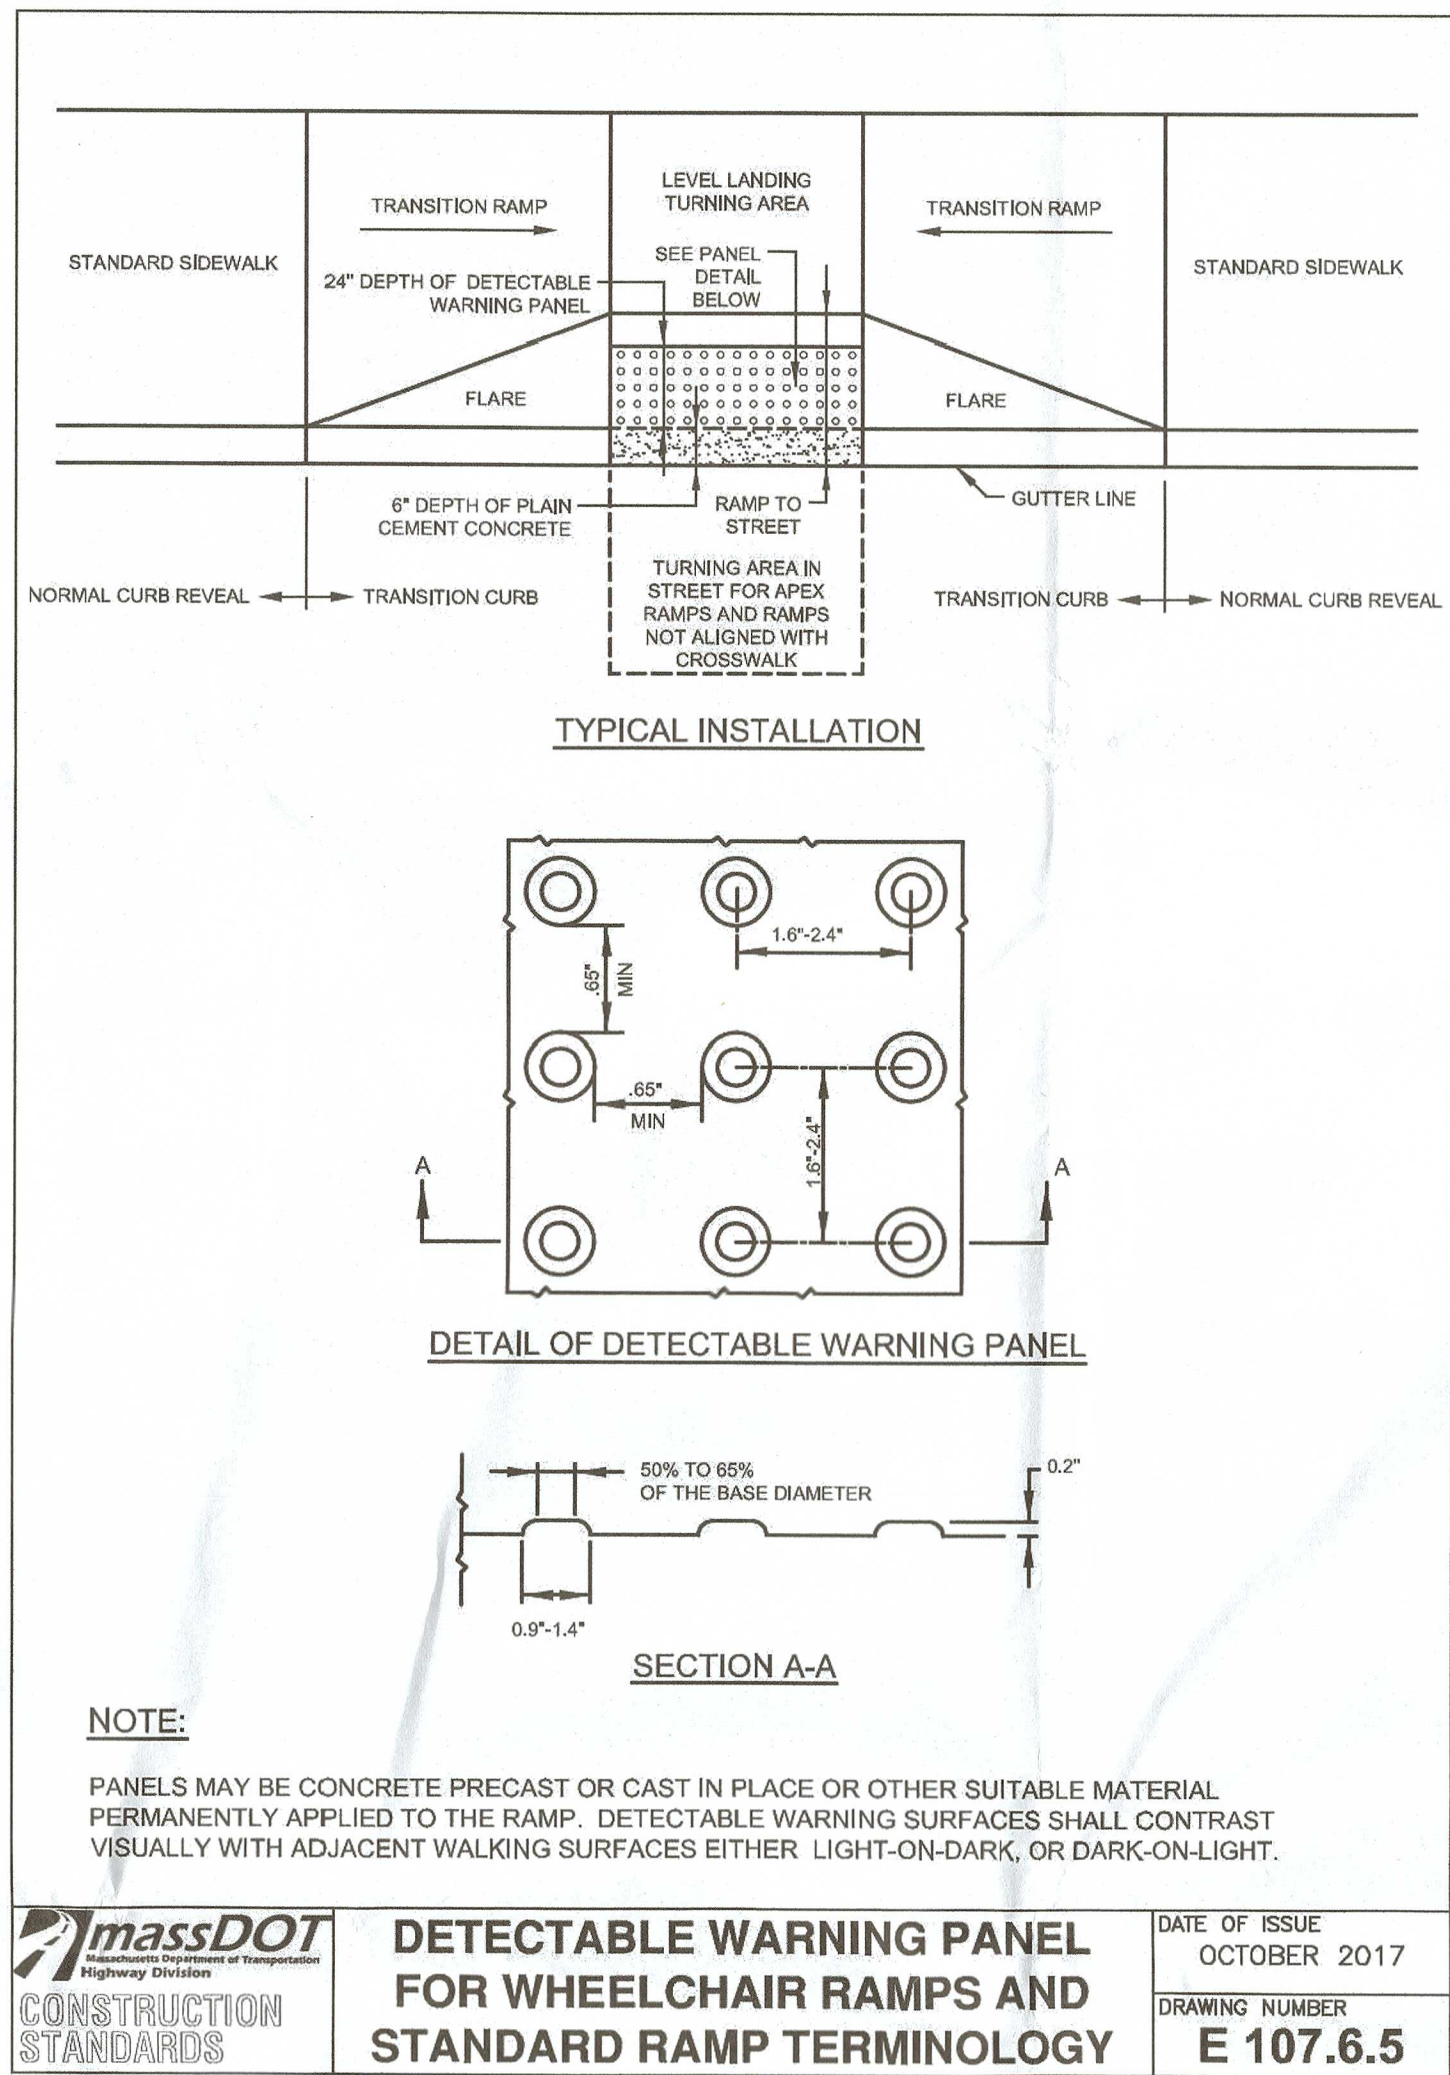

NOTES:
1. BIKE RACK BELSON OUTDOORS HEAVY-DUTY CHALLENGER/WAVE BIKE RACK, 5 LOOPS 7 BIKES MODEL # H38-7-R-SF, OR APPROVED EQUAL.
2. COLOR SHALL BE BLACK.

NO.	DATE	DESCRIPTION	DESIGNER	REVIEWER
1.	03/20/2022	RESPONSE TO NEW BEDFORD DPI COMMENTS	JHD	KCM
2.	5/17/2022	RESPONSE TO NEW BEDFORD DPI COMMENTS	JHD	KCM

COMMONWEALTH OF MASSACHUSETTS
REGISTERED PROFESSIONAL ENGINEER
6/17/2022

SCALE: HORZ.: N.T.S. VERT.: 1"=10'-0" GRAPHIC SCALE

FUSS & O'NEILL
108 MYRTLE STREET, SUITE 902
QUINCY, MA 02171
www.fussandoneill.com


BRISTOL COMMUNITY COLLEGE
CONSTRUCTION DETAILS
198 HERMAN MELVILLE BOULEVARD
NEW BEDFORD, MASSACHUSETTS

PROJ No.: 20210350 A10
DATE: 01/12/2022

CD-503



NOT TO SCALE

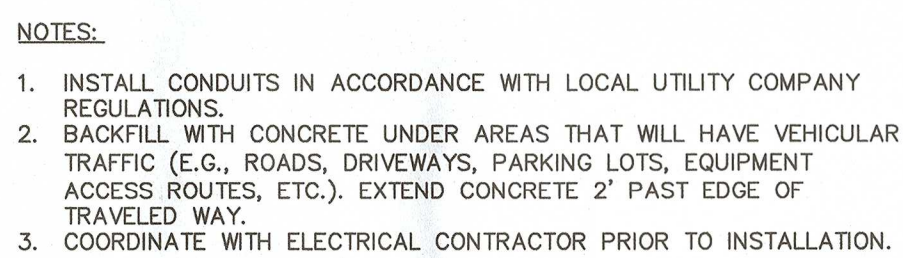

CONDUIT DEPTHS	
SERVICE	DIM "A"
PRIMARY	36"
SECONDARY	24"
SPARE TO UTILITY POLE	36"
TELEPHONE	24"
CABLE TV	24"
SITE LIGHTING	24"

SCALE: NOT TO SCALE



THE STANDARD CDS2015-4-C CONFIGURATION IS SHOWN. ALTERNATE CONFIGURATIONS ARE AVAILABLE AND ARE LISTED BELOW. SOME CONFIGURATIONS MAY BE COMBINED TO SUIT SITE REQUIREMENTS.

CONFIGURATION DESCRIPTION

GRATED INLET ONLY (NO INLET PIPE)
GRATED INLET WITH INLET PIPE OR PIPES
CURB INLET ONLY (NO INLET PIPE)
CURB INLET WITH INLET PIPE OR PIPES
SEPARATE OIL BAFFLE (SINGLE INLET PIPE REQUIRED FOR THIS CONFIGURATION)
SEDIMENT WEIR FOR NJDEP / NJCAT CONFORMING UNITS

SITE SPECIFIC DATA REQUIREMENTS

STRUCTURE ID				
WATER QUALITY FLOW RATE (CFS OR L/s)				*
PEAK FLOW RATE (CFS OR L/s)				*
RETURN PERIOD OF PEAK FLOW (YRS)				*
SCREEN APERTURE (2400 OR 4700)				*
PIPE DATA:		I.E.	MATERIAL	DIAMETER
INLET PIPE #		*	*	*
INLET PIPE 2		*	*	*
OUTLET PIPE		*	*	*
RM ELEVATION				*
ANTI-FLOTATION BALLAST			WIDTH	HEIGHT
			*	*
NOTES/SPECIAL REQUIREMENTS:				
* PER ENGINEER OF RECORD				

GENERAL NOTES:


1. CONTRACTOR TO PROVIDE ALL MATERIALS UNLESS NOTED OTHERWISE.
2. DIMENSIONS MARKED WITH "X" ARE REFERENCE DIMENSIONS. ACTUAL DIMENSIONS MAY VARY.
3. CONTRACTOR TO PROVIDE ALL DIMENSIONS AND WEIGHTS. IF ANY, PLEASE CONTACT YOUR CONTEXT ENGINEERED SOLUTIONS LLC REPRESENTATIVE. www.comtechcs.com
4. CONTRACTOR TO PROVIDE ALL DIMENSIONS AND INFORMATION CONTAINED IN THIS DRAWING.
5. STRUCTURE SHALL MEET ASDH10 AND CANS SHALL MEET ASDH10. A 3000 LBS LOAD, ASSUMING GROUNDWATER ELEVATION SHALL BE 10' ABOVE THE TOP OF THE CYLINDER.
6. PLY HYDRAULIC SHEAR PLATE IS PLACED ON SHELF AT BOTTOM OF SCREEN CYLINDER. REMOVE AND REPLACE AS NECESSARY DURING MAINTENANCE OF THE SCREEN.

INSTALLATION NOTES:

- A. ANY SIZE BACKFILL, DEPTH AND/OR ANTI-POLLUTION PROVISIONS ARE SITE-SPECIFIC DESIGN CONSIDERATIONS AND SHALL BE DETERMINED BY A LICENSED ENGINEER OF RECORD.
- B. CONTRACTOR TO PROVIDE EQUIPMENT WITH SUFFICIENT LIFTING AND REACH CAPACITY TO LIFT AND SET THE CO2 MANIFOLD. STRUCTURE SHALL BE INSTALLED AND SET IN PLACE.
- C. CONTRACTOR TO ADJ. JOINT RELATIVE BETWEEN ALL STRUCTURE SECTIONS, AND ASSEMBLE STRUCTURE.
- D. CONTRACTOR TO PROVIDE, INSTALL, AND GREAT PRESSURE WATER TIGHTENING OF ALL JOINTS.
- E. CONTRACTOR TO TAKE APPROPRIATE MEASURES TO ASSURE CLOSURE IN WATER TIGHT, HOLDING WATER TO FLOWLINE INTERNAL. IT IS THE CONTRACTOR'S RESPONSIBILITY TO PROVIDE ALL NECESSARY MEASURES TO ACHIEVE THE INTENT OF THE DESIGN.

CONTECH
ENGINEERED SOLUTIONS LLC
www.contechES.com
Centre Pointe Dr., Suite 400, West Chester, OH
610.696.6600 FAX 610.696.6601 E-MAIL info@contechES.com

 CDS2015-4-C
 INLINE CDS
 STANDARD DETAIL




NOT TO SCALE



NOTES

1. SEED MIX SHALL BE NEW ENGLAND WETLAND PLANTS "NEW ENGLAND EROSION CONTROL/RESTORATION MIX FOR DETENTION BASINS AND MOIST SITES".


NOT TO SCALE

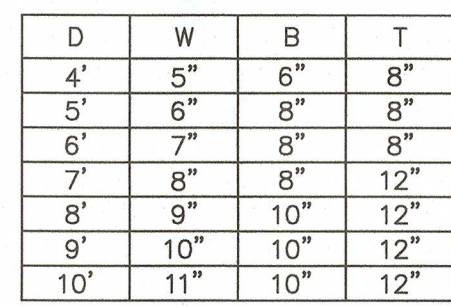

NOT TO SCALE



NOT TO SCALE

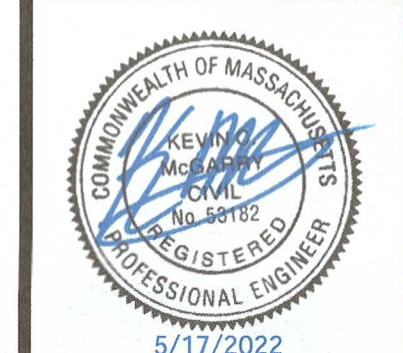


SCALE:	
HORIZ: N.T.S.	
VERT.:	
DATUM:	
HORIZ: 1"=100'	
VERT.:	



0


GRAPHIC SCALE

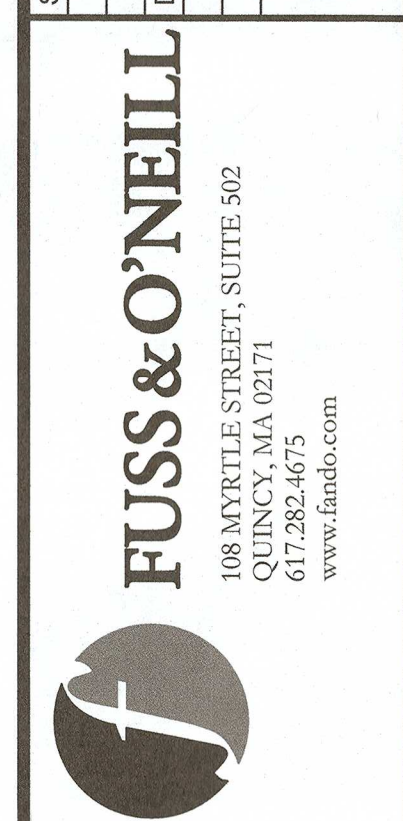

BRISTOL COMMUNITY COLLEGE
CONSTRUCTION DETAILS
198 HERMAN MELVILLE BOULEVARD
NEW BEDFORD
MASSACHUSETTS

PROJ. No.: 20210350.A10
DATE: 01/12/2022

CD-504

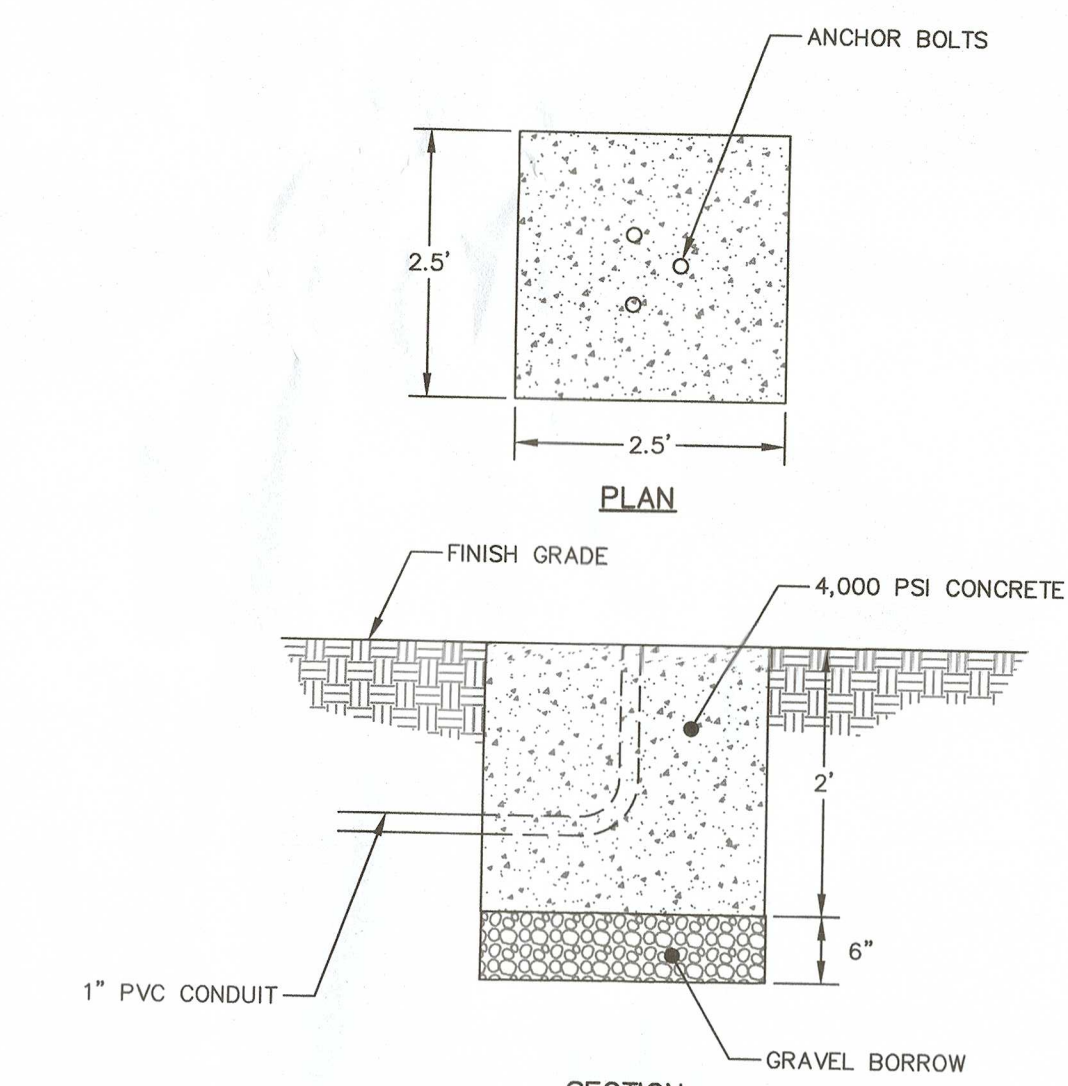

NOTE: COORDINATE WORK AND ANCHOR BOLT PATTERN WITH ELECTRICAL CONTRACTOR AND EV STATION PROVIDER.
VEHICLE CHARGING STATION FOUNDATION
NOT TO SCALE



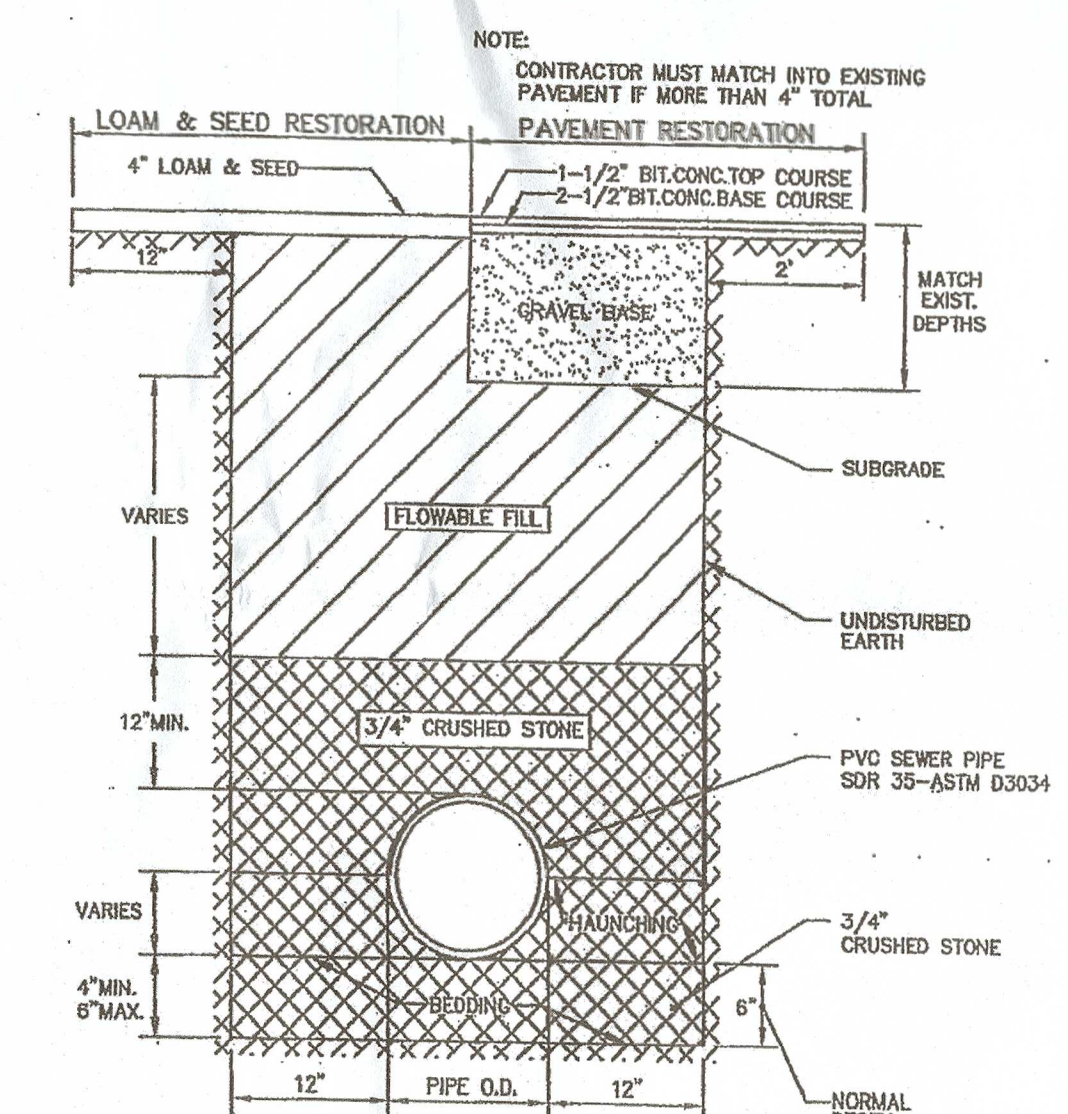



FIGURE 1
TYPICAL TRENCH DETAIL
(ALL PIPES LESS THAN 20\"/>

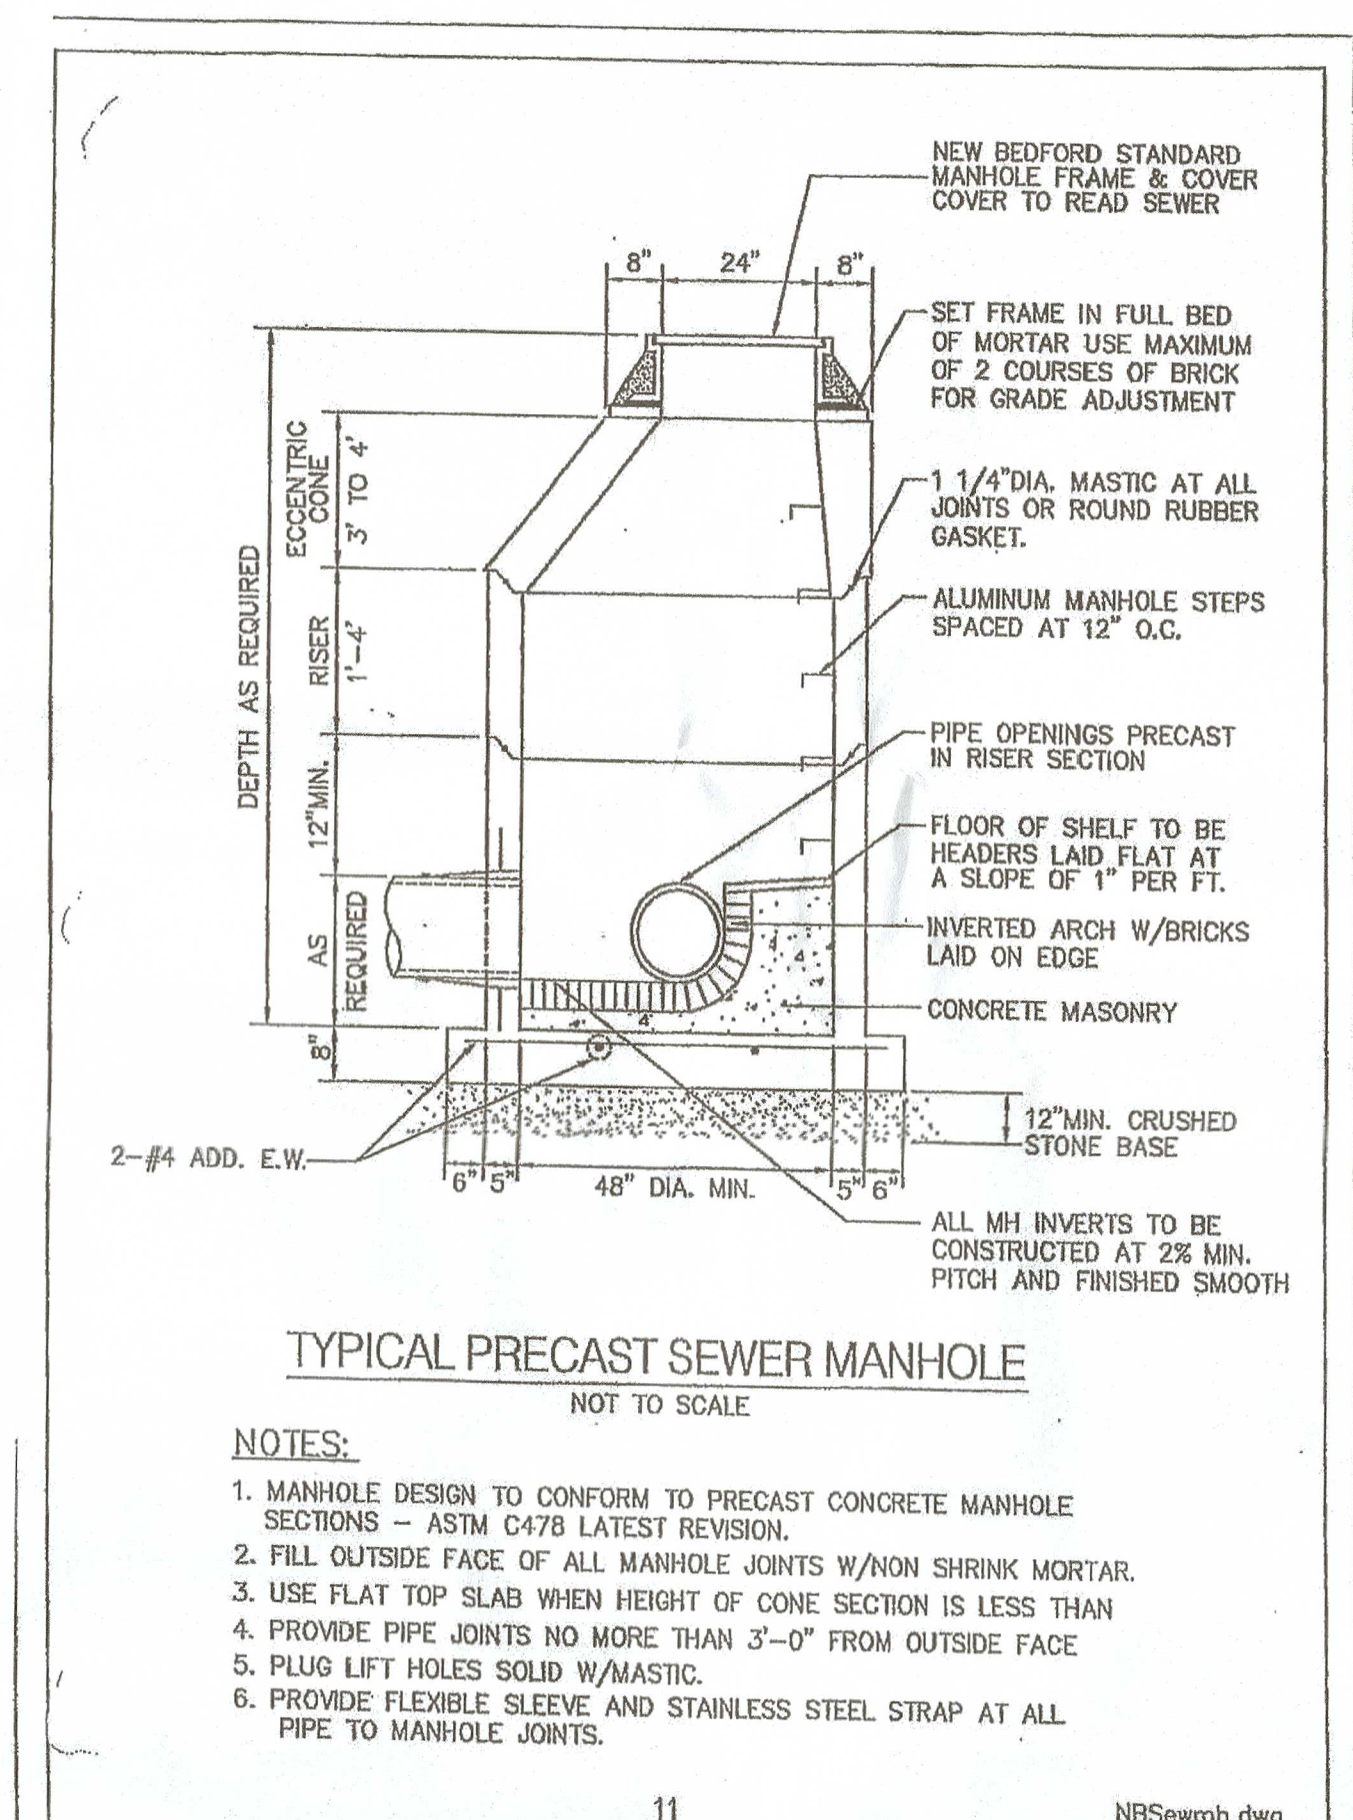



- NOTES:**
1. MANHOLE DESIGN TO CONFORM TO PRECAST CONCRETE MANHOLE SECTIONS - ASTM C478 LATEST REVISION.
 2. FILL OUTSIDE FACE OF ALL MANHOLE JOINTS W/ NON SHRINK MORTAR.
 3. USE FLAT TOP SLAB WHEN HEIGHT OF CONE SECTION IS LESS THAN 5'-0\"/>
 4. PROVIDE PIPE JOINTS NO MORE THAN 3'-0\"/>
 5. PLUG LIFT HOLES SOLID W/ MASTIC.
 6. PROVIDE FLEXIBLE SLEEVE AND STAINLESS STEEL STRAP AT ALL PIPE TO MANHOLE JOINTS.

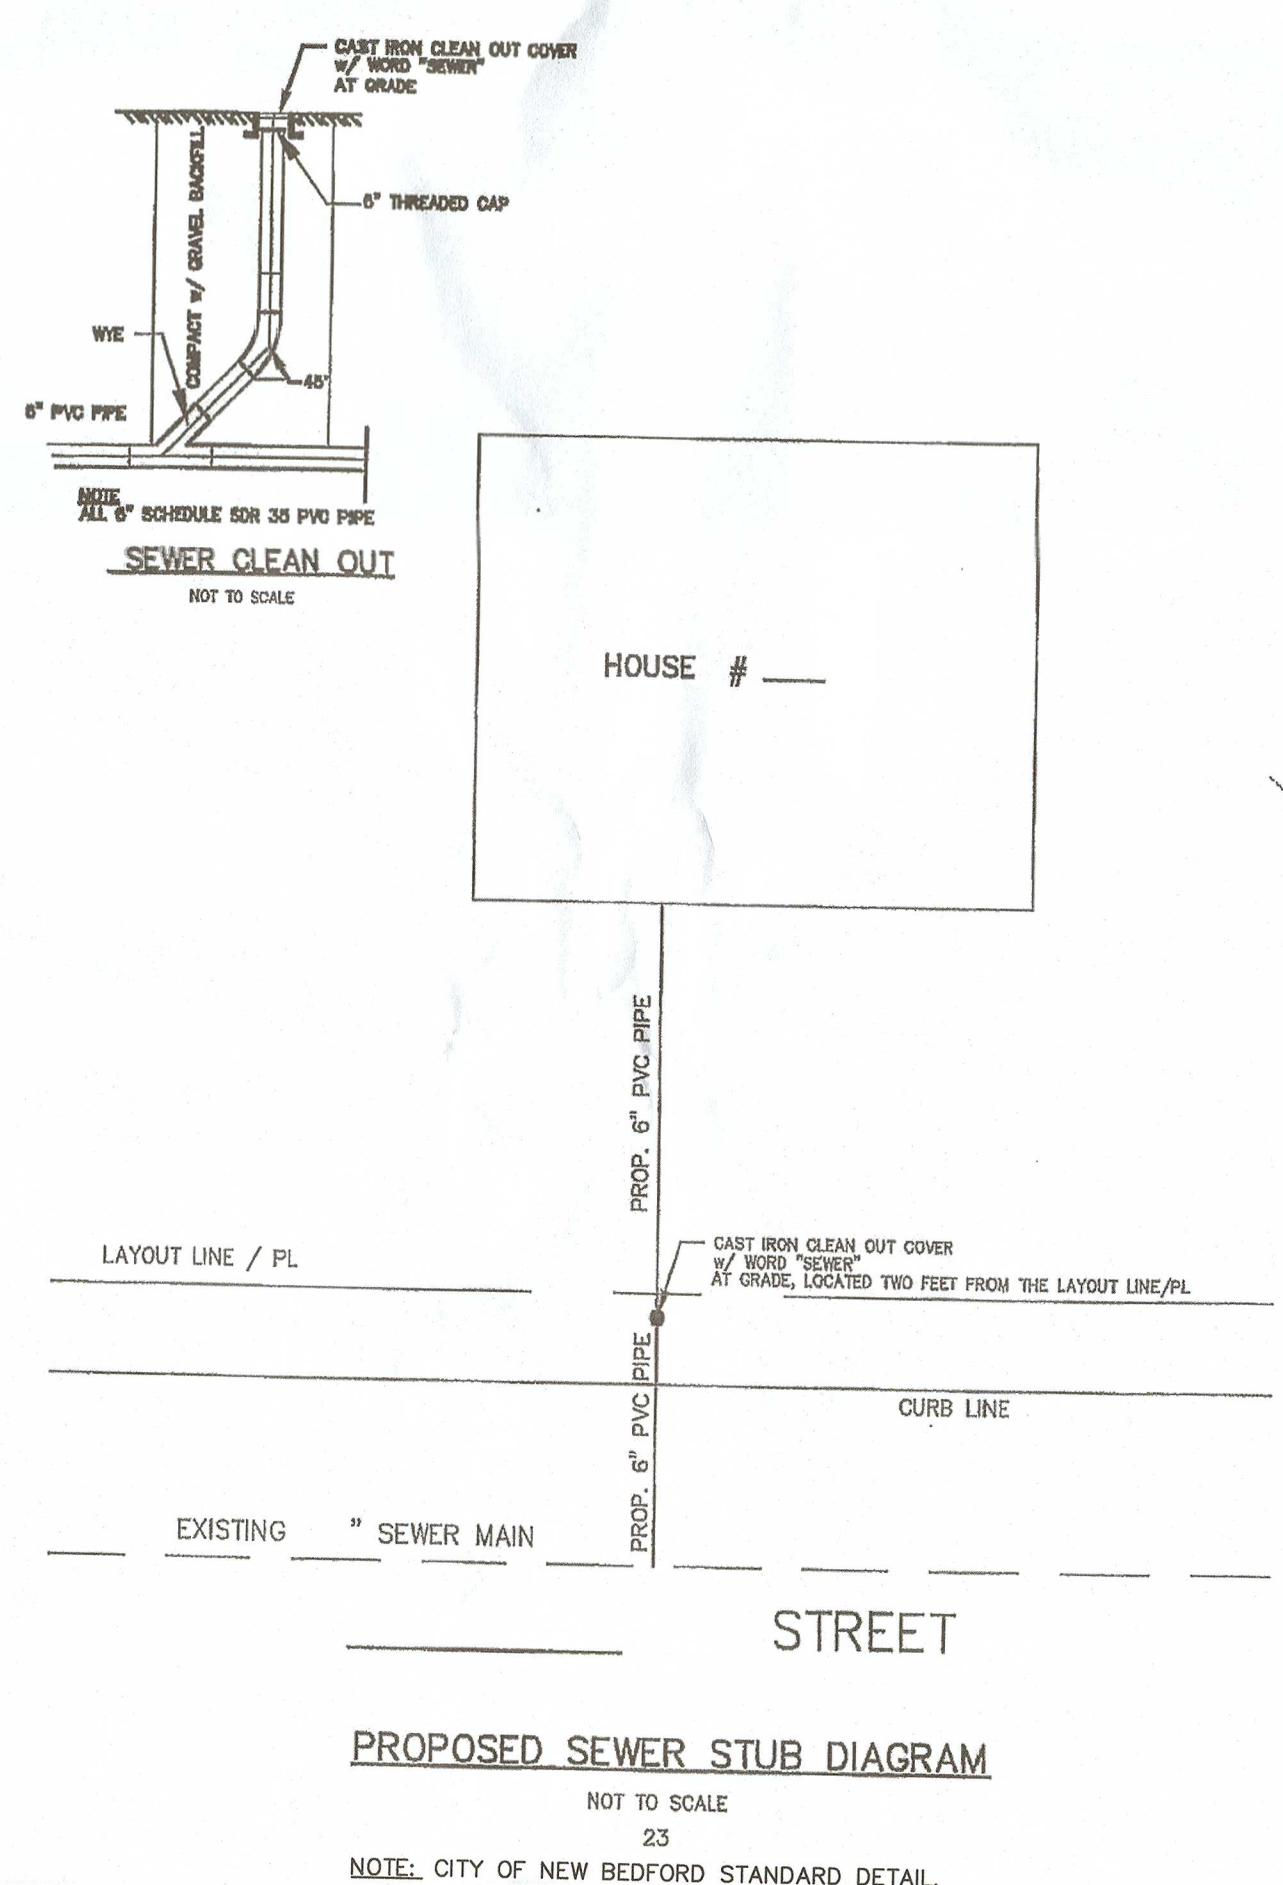


PROPOSED SEWER STUB DIAGRAM
NOT TO SCALE

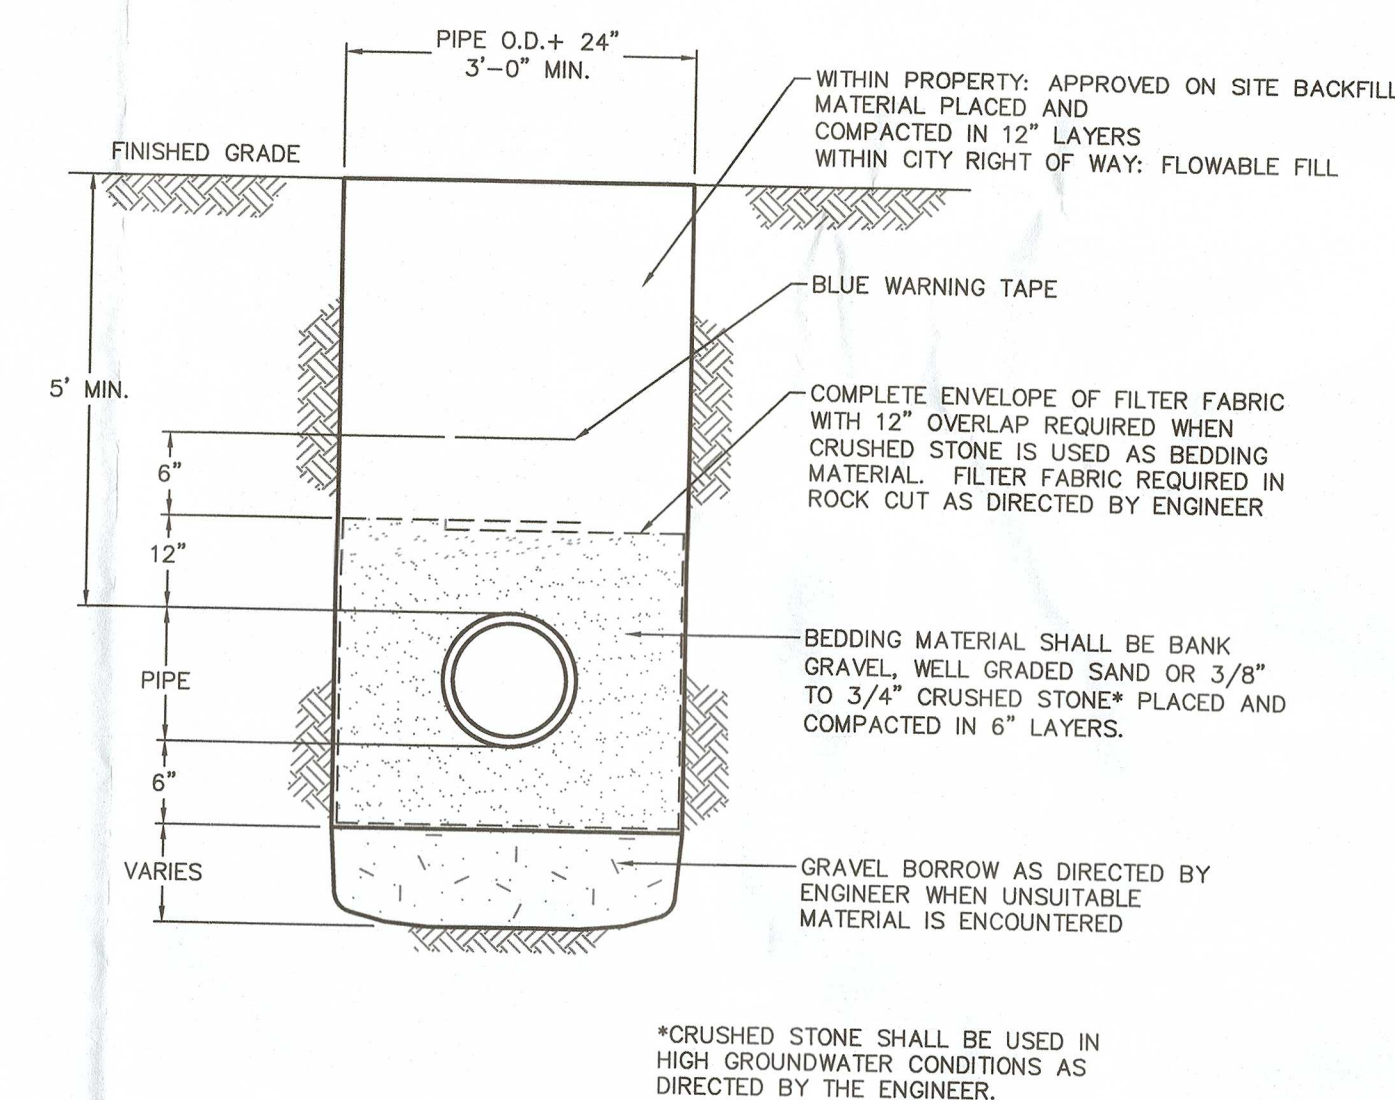


WATER SERVICE TRENCH
NOT TO SCALE

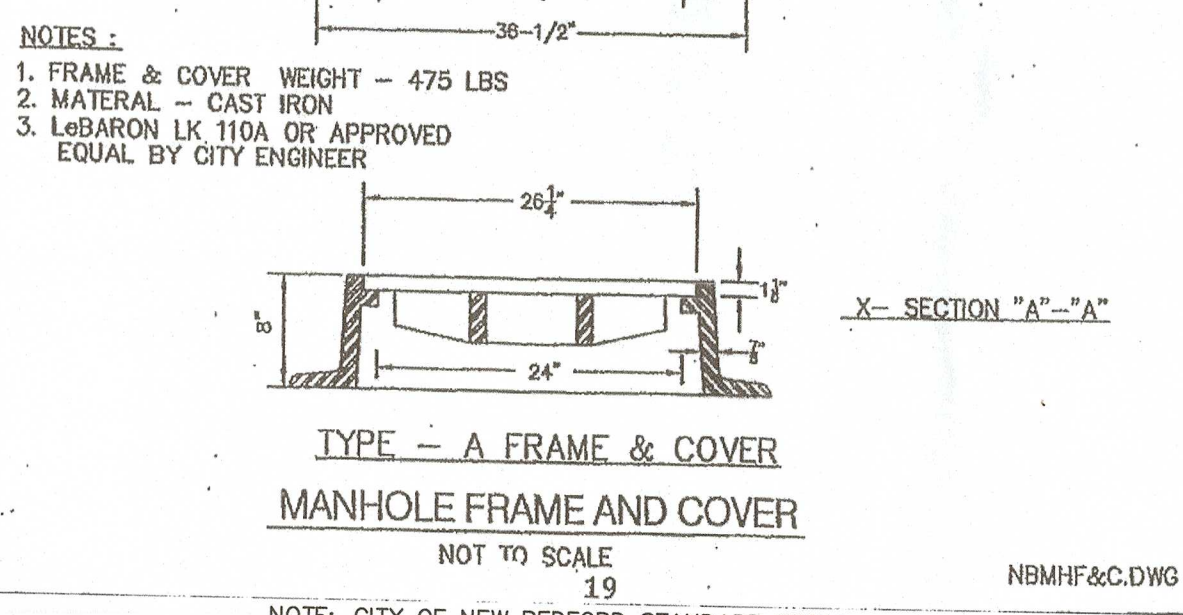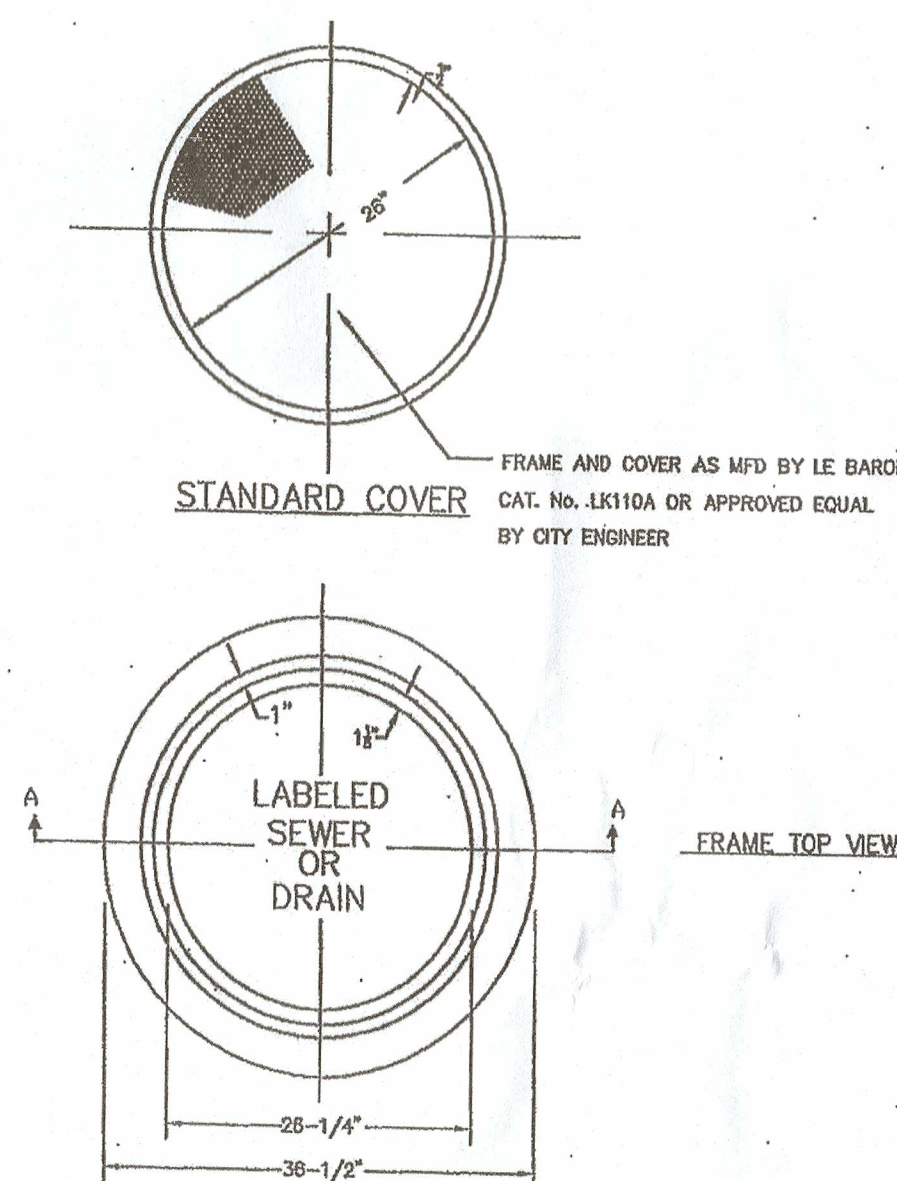

TYPE - A FRAME & COVER
MANHOLE FRAME AND COVER
NOT TO SCALE

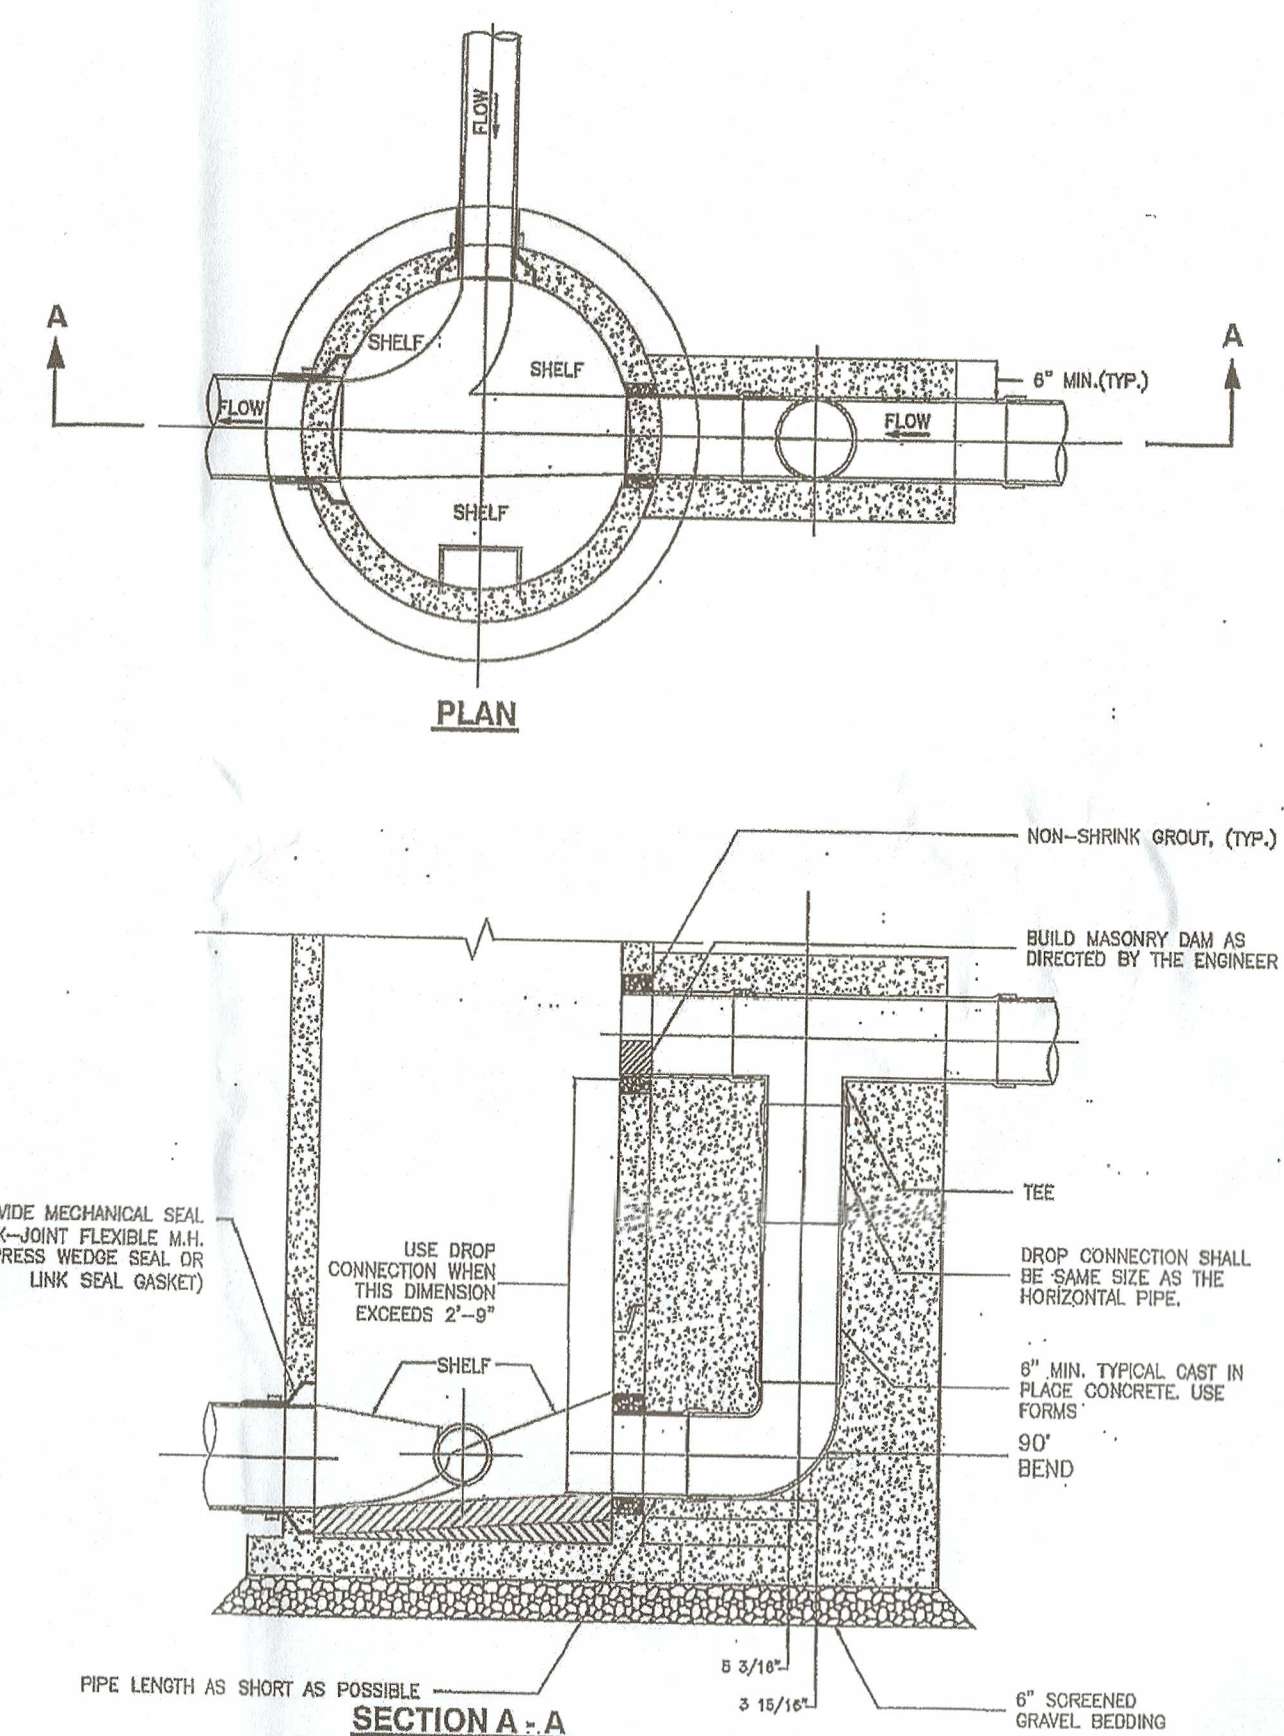

OUTSIDE DROP MANHOLE DETAIL
NOT TO SCALE

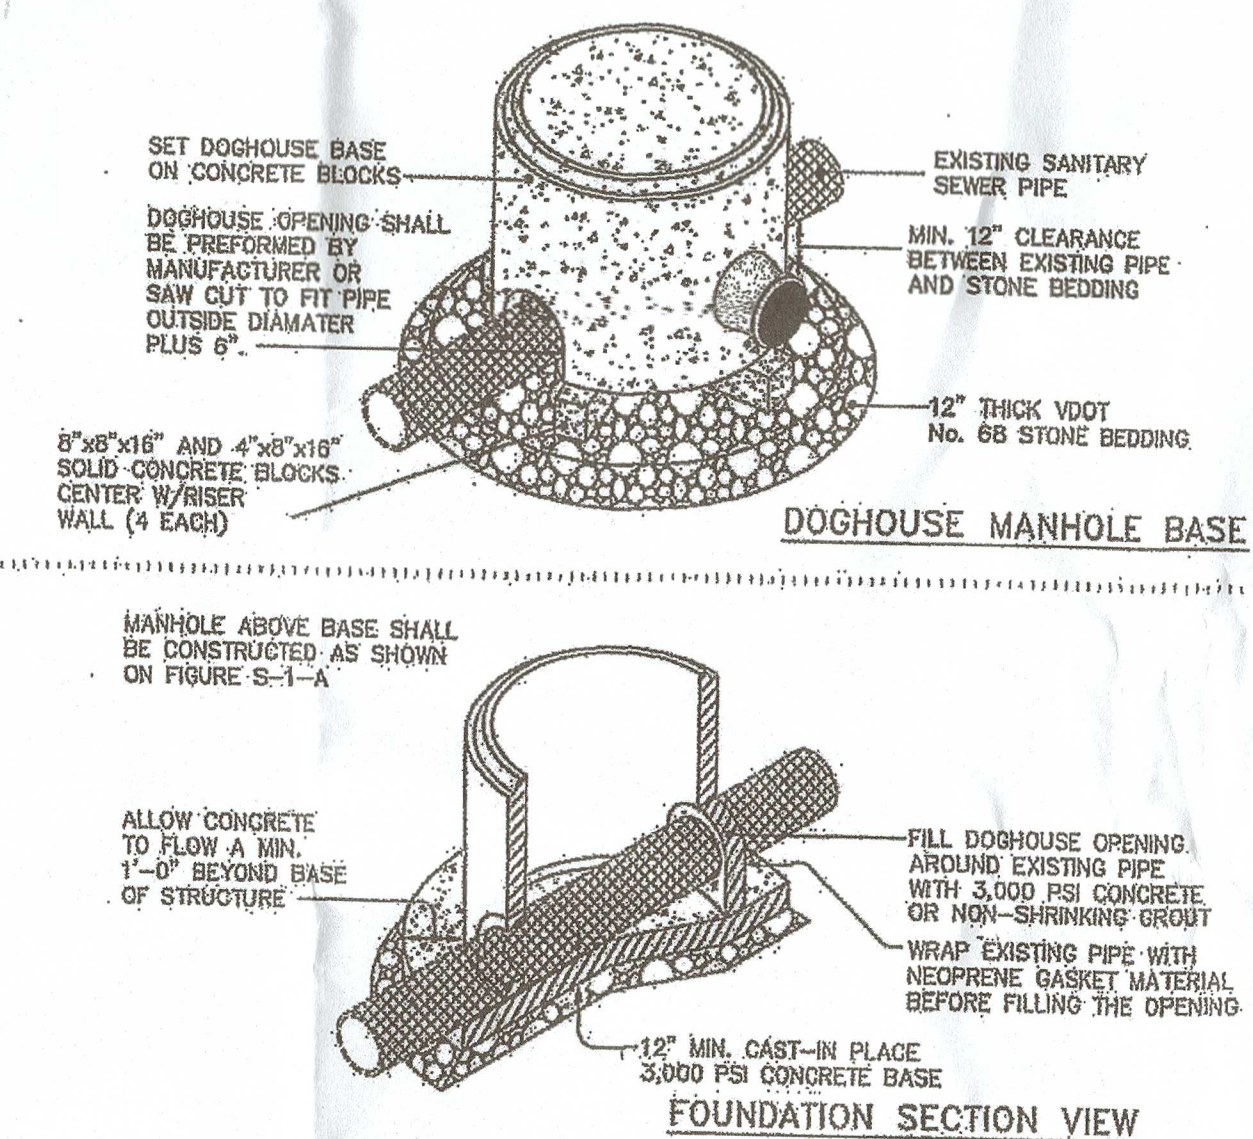

- NOTES:**
1. CONSTRUCT A FORMED INVERT FROM NEW SEWER LINE TO ALLOW FLOW TO THE EXISTING PIPE.
 2. POUR A SHELVE TO THE LOWER HALF OF THE EXISTING PIPE.
 3. CUT AND REMOVE THE TOP HALF OF EXISTING PIPE TO WITHIN 6\"/>
- TYPICAL MANHOLE BASE**
SHOWING \"DOGHOUSE\" INSTALLATION

NO.	DATE	DESCRIPTION	DESIGNER	REVIEWER
1.	02/20/2022	RESPONSE TO NEW BEDFORD COMMENTS	JMD	KCM
2.	5/17/2022	RESPONSE TO NEW BEDFORD COMMENTS	JMD	KCM

FUSS & O'NEILL
108 MYRTLE STREET, SUITE 502
QUINCY, MA 02171
www.fussandoneill.com

BRISTOL COMMUNITY COLLEGE
CONSTRUCTION DETAILS
198 HERMAN MELVILLE BOULEVARD
NEW BEDFORD
MASSACHUSETTS

PROJ. No.: 20210350.A10
DATE: 01/12/2022

CD-505